NOTE:

THE LOCATION OF UTILITIES IS APPROXIMATE ONLY, AND THE EXACT LOCATION SHOULD BE DETERMINED BY CONSULTING THE MUNICIPAL AUTHORITIES AND UTILITY COMPANIES CONCERNED. THE CONTRACTOR SHALL BE RESPONSIBLE FOR ADEQUATE PROTECTION FROM DAMAGE DURING CONSTRUCTION.

"THE COMPOSITE UTILITY PLANS HAVE BEEN REVIEWED BY IBI GROUP FOR CONFORMITY TO THE DESIGN CONCEPT FOR THE DEVELOPMENT AND FOR GENERAL ARRANGEMENT ONLY AND AS SUCH SHALL NOT RELIEVE THE CONTRACTOR OF RESPONSIBILITY FOR ERRORS OR OMISSIONS IN EITHER LAYOUT, MATERIALS OR WORKMANSHIP.

THIS DRAWING IS A COMPILATION OF OTHER UTILITY DESIGNS AND DOES NOT INDICATE IN ANY WAY THAT THE PARTY SIGNING THIS DRAWING HAS DESIGNED OR APPROVED THE RESPECTIVE UTILITY PLANTS INDICATED ON THIS DRAWING. THE DRAWING WAS PREPARED TO BE USED AS REFERENCE ONLY AS PER THE REQUIREMENTS OF THE CITY OF OTTAWA. IT IS THE CONTRACTOR'S RESPONSIBILITY TO ENSURE IT HAS REVIEWED THE CURRENT DESIGNS BY HYDRO, STREET LIGHTING, GAS, BELL, CANADA POST, O.C. TRANSPO, CABLE TV AND ANY OTHER PARTIES INCLUDED BUT NOT MENTIONED AND COMPLETE THE INSTALLATION IN ACCORDANCE WITH THE REQUIREMENTS OF THE STAKEHOLDER UTILITY DESIGNS."

CONTRACTOR TO NOTE THAT THIS DRAWING IS NOT TO BE SCALED OR USED FOR LAYOUT PURPOSES.


STREETLIGHT AND PEDESTALS (BELL/CABLE) TO BE A MINIMUM OF 1.5m AWAY FROM DRIVEWAYS AND A MINIMUM OF 1.0m AWAY FROM CATCHBASIN LEAD.

STREETLIGHT TO BE A MINIMUM OF 2.1m AWAY FROM CENTER OF TRANSFORMER. (PER UTS0012, UTS0013)


PEDESTAL (BELL & CABLE) TO BE 2.0m MINIMUM FROM FIRE HYDRANTS AND STREETLIGHTS.


SERVICES FOR HOUSES TO BE MINIMUM OF 3.65m FROM CENTER OF TRANSFORMERS PER CITY STD R20 (3.65m CLEAR PREFERABLE PER HYDRO OTTAWA DETAILS UTS0012 AND UTS0013).

STREETLIGHTS TO BE A MINIMUM 2.0m CLEAR FROM FIRE HYDRANTS. BELL AND CABLE PEDESTALS AT LOCATIONS WHERE THERE IS NO TRANSFORMER ARE TO BE INSTALLED CLEAR OF ACCESS EASEMENTS.

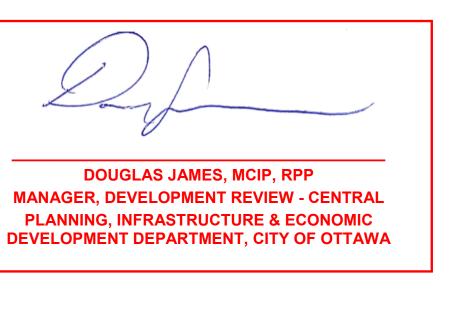





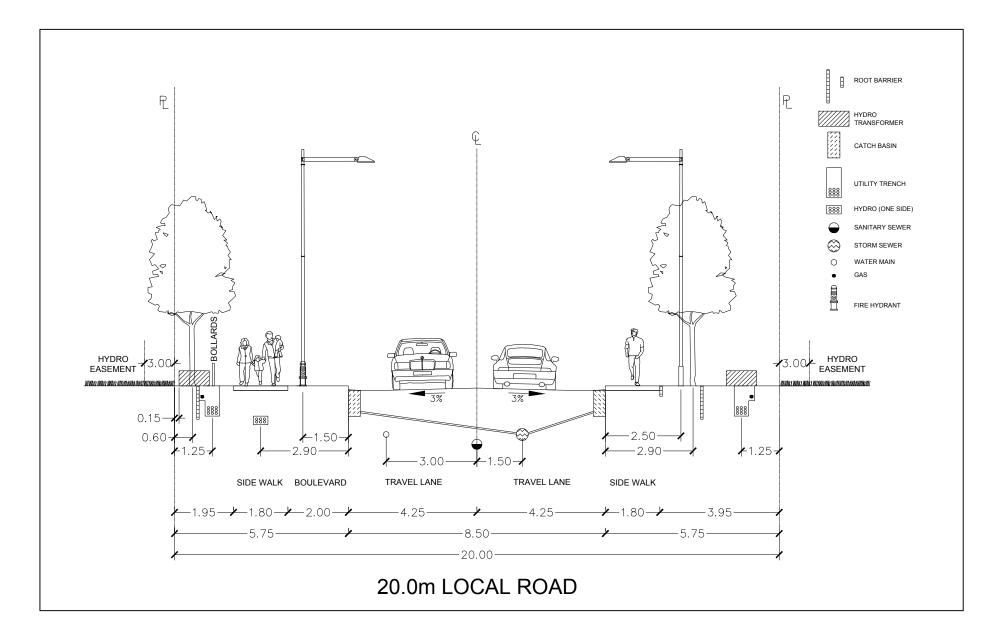


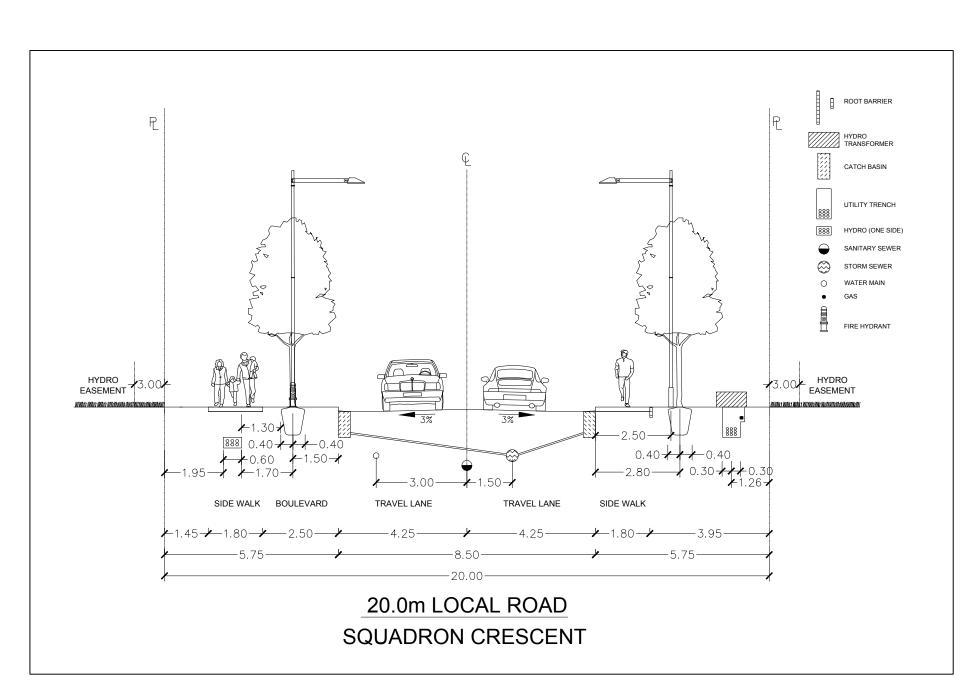

By Jamesdo at 9:59 am, Feb 11, 2020

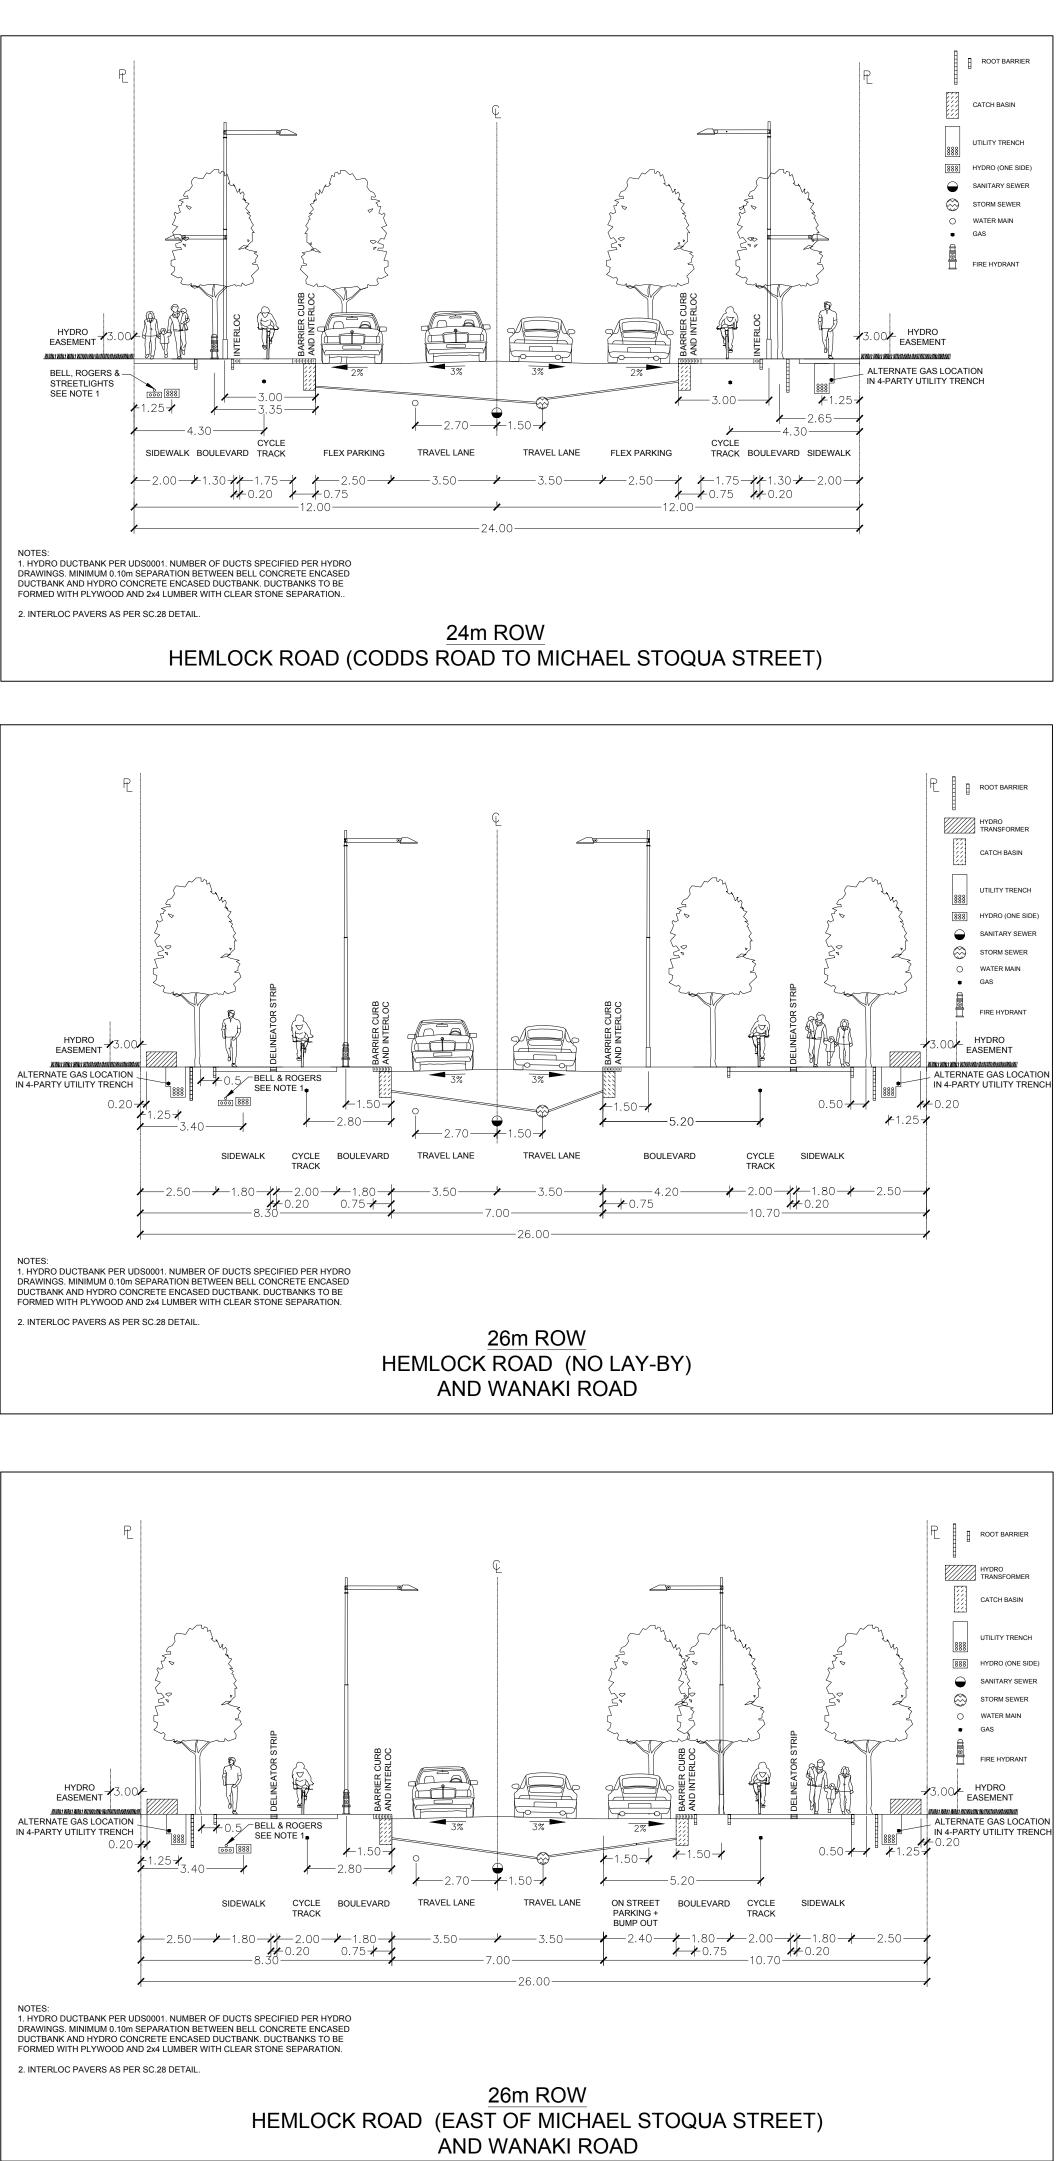

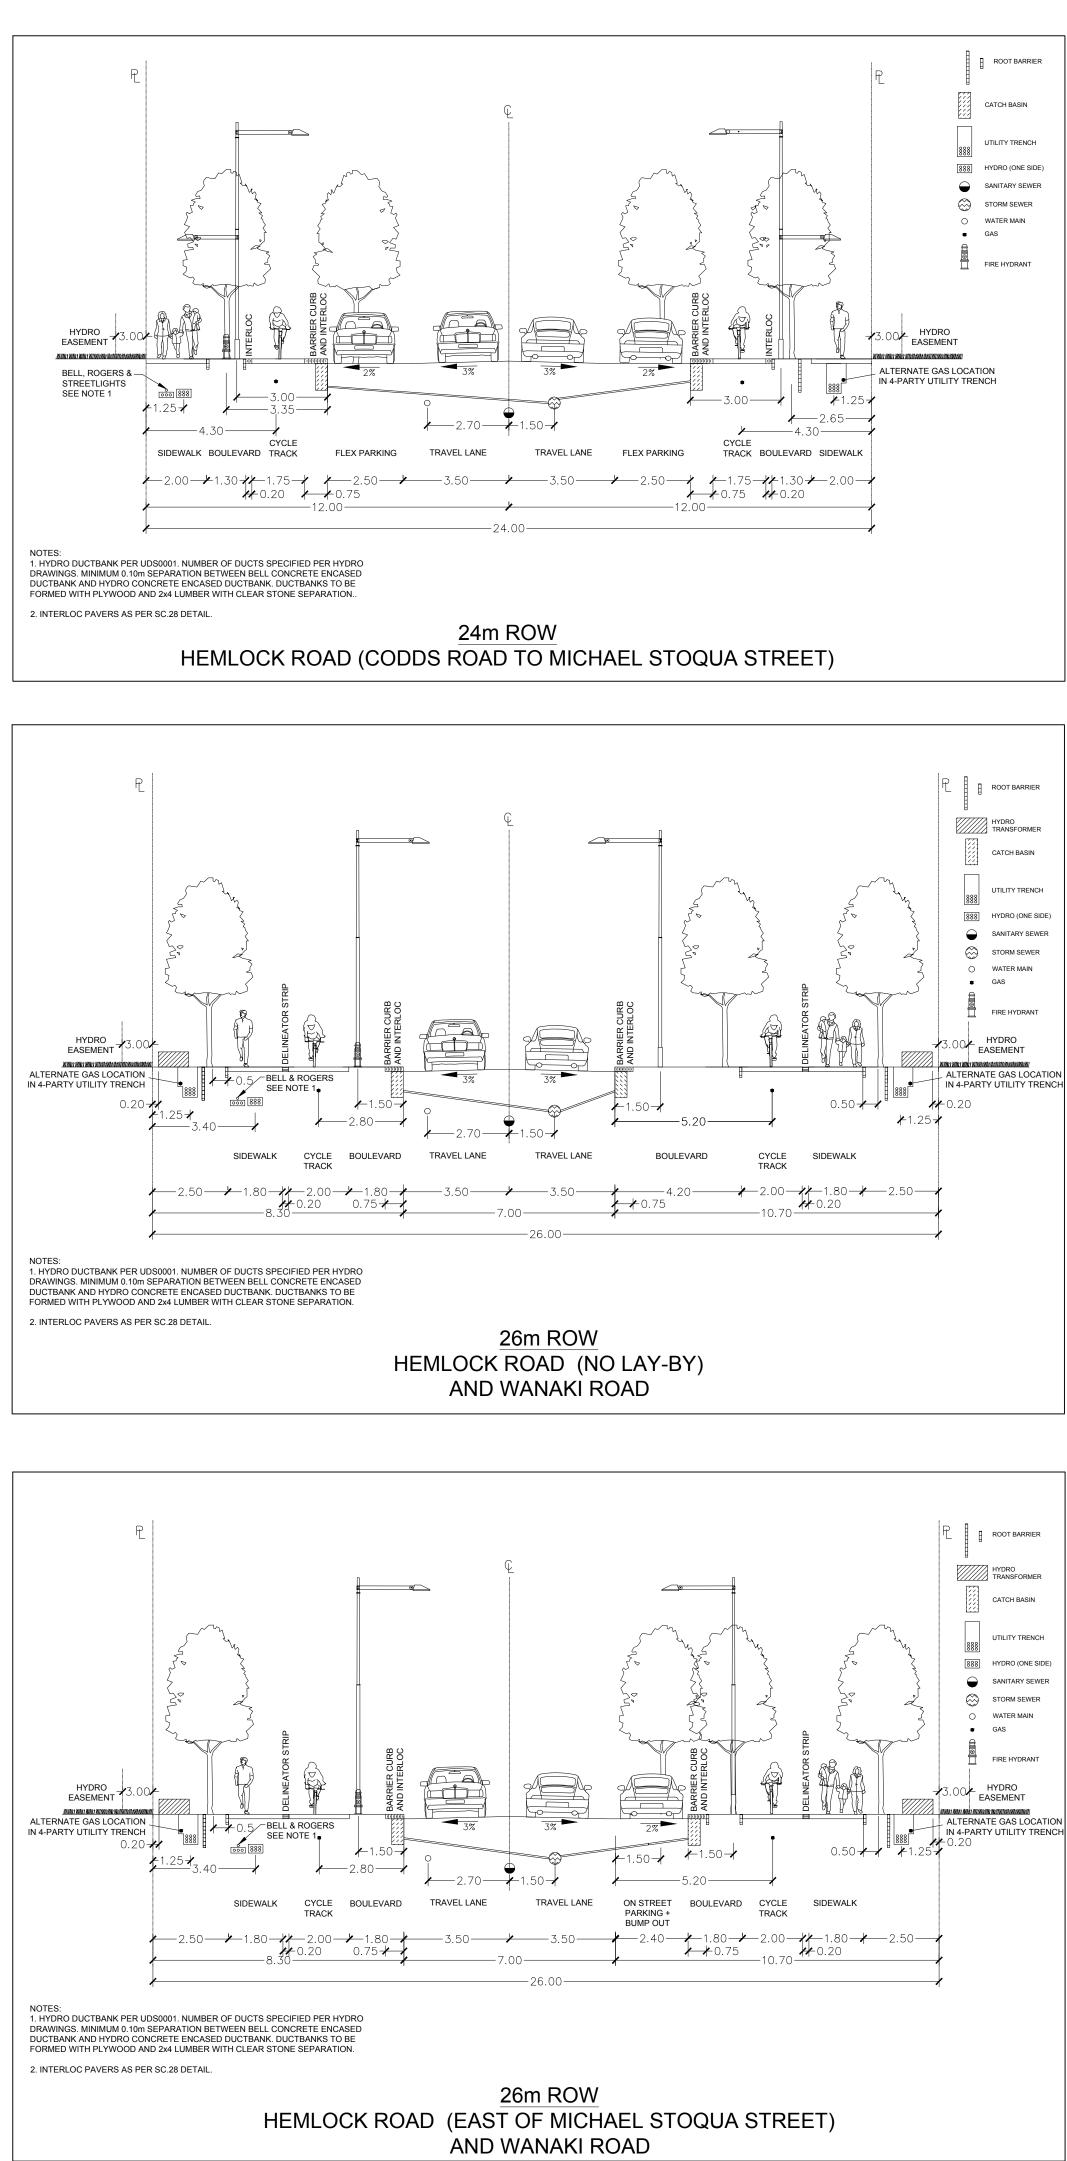

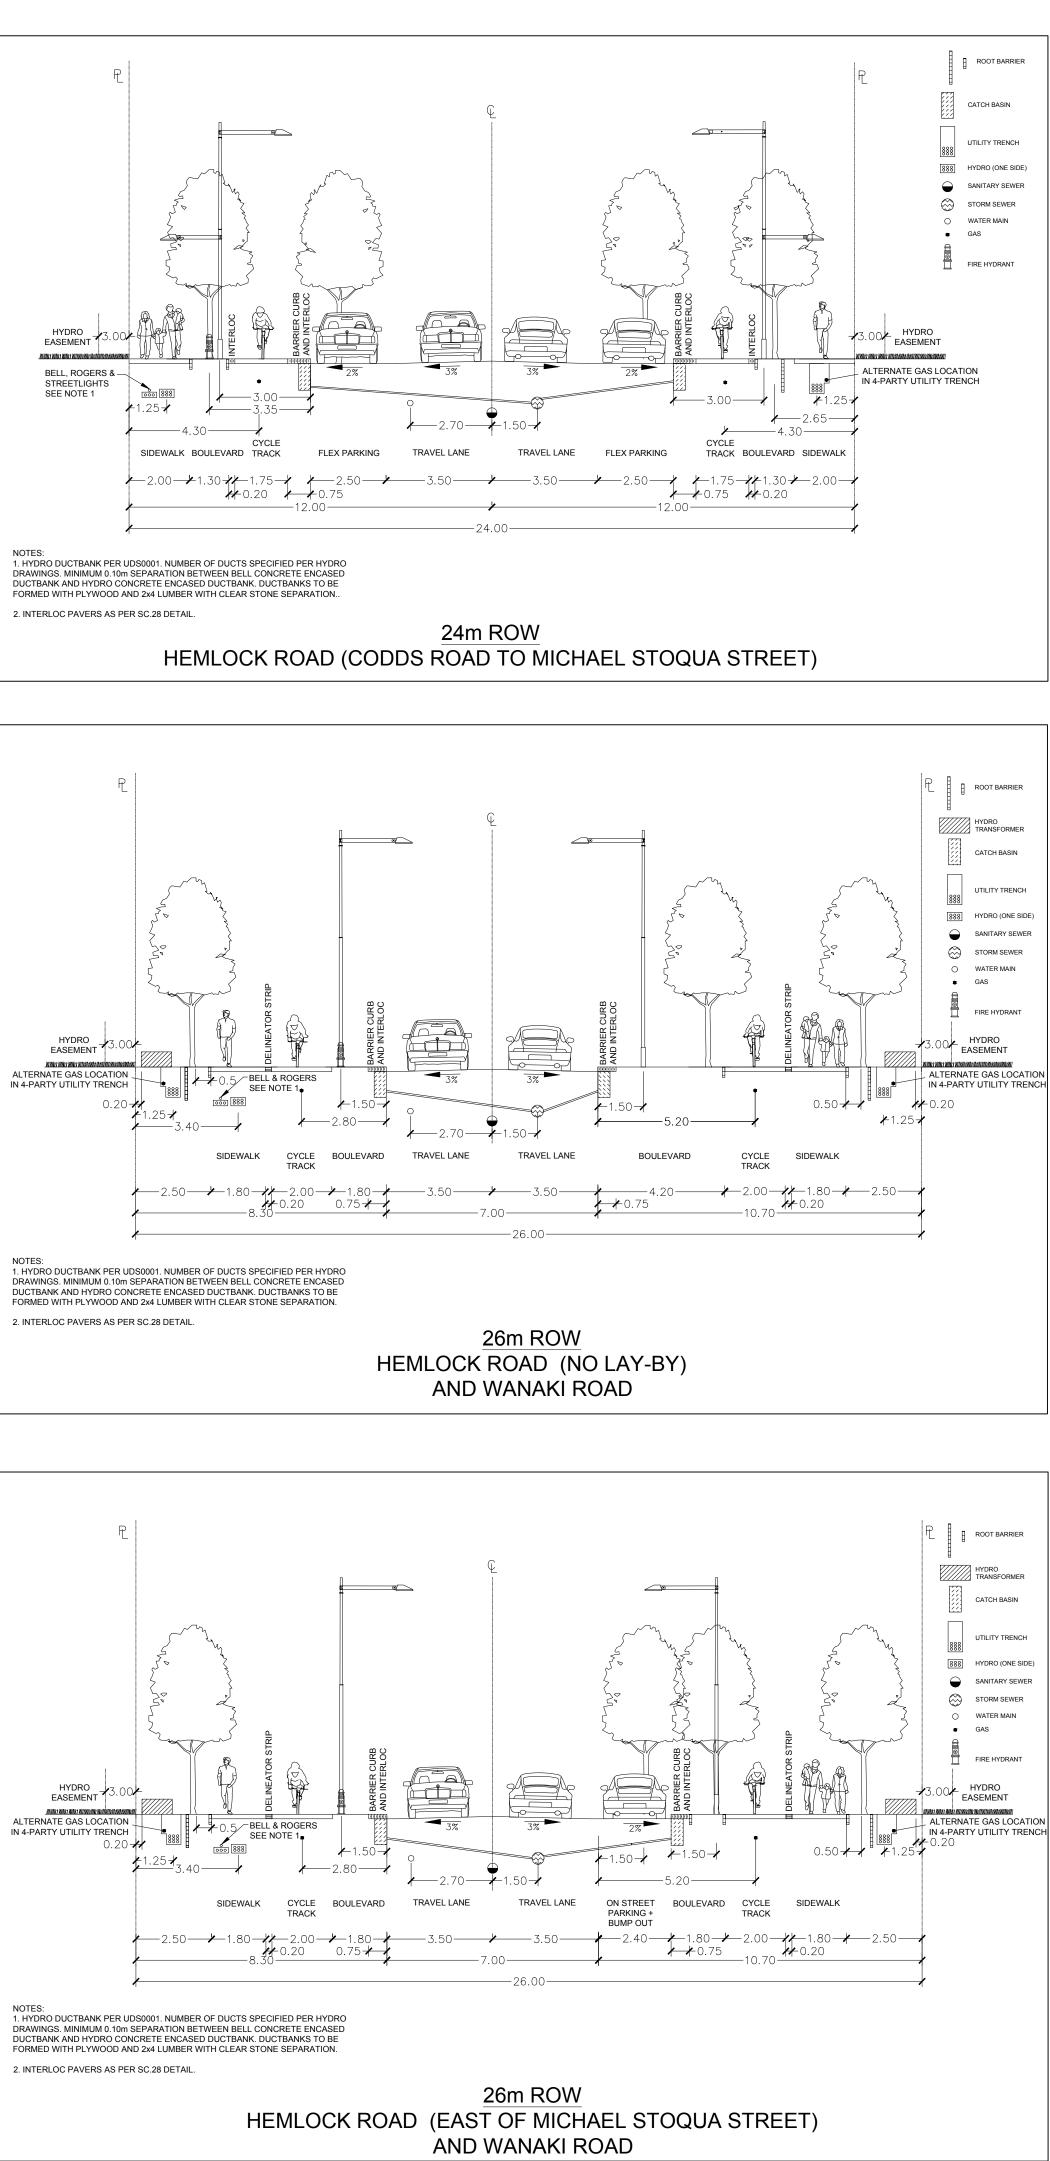

Date			2017
Plan Number			
		\sum	
NonFort			
	EN OVER STORE		
		e	
			No.
16 REVISED SECTION FO		J.I.M.	2020: 02: 03
15 REVISED 20m LOCAI FOR SQUADRON CRE	L ROAD SECTION SCENT SECTION ADDED	J.I.M. J.I.M.	2020: 01: 24 2020: 01: 21
14 FOR SQUADRON CRE 13 GENERAL CROSS SE 13 ADD DELINEATOR ST	ESCENT CTION REVISIONS	J.I.M.	2020: 01: 21
12 ISSUED FOR CONSTR		J.I.M. J.I.M.	2017: 08: 02 2017: 06: 16
11 REVISED PER CITY C 10 REVISED PER MOECC		J.I.M. J.I.M.	2017:06:16
9 ISSUED FOR TENDER		J.I.M. J.I.M.	2017: 03: 23 2017: 02: 16
8 SUBMISSION FOR MC		J.I.M. J.I.M.	2017:02:16
6 GENERAL REVISIONS		J.I.M.	2017: 02: 06 2017: 01: 25
5 SUBMISSION No.3 FC 4 REVISED SECTIONS F		J.I.M. J.I.M.	2017:01:25
3 VEDETTE WAY SECTI 2 SUBMISSION No.2 FO		J.I.М.	2016:11:16
2 SUBMISSION No.2 FC 1 SUBMISSION No.1 FC		J.I.M. J.I.M.	2016: 11: 04 2016: 07: 08
No. REV	/ISIONS	Ву	Date
	ANDS COMPAN		NADA
Société II 30 Metcalfe	MMOBILIÈRE D	U CA	NADA
	MMOBILIÈRE D Street Suite 60 K1P 5L4	U CA	NADA
30 Metcalfe Ottawa, On	MMOBILIÈRE D Street Suite 60 K1P 5L4 77	U CA	NADA
Société II 30 Metcalfe Ottawa, On 613 998 77 IBI GR 400 – 3 Ottawa	MMOBILIÈRE D Street Suite 60 K1P 5L4 77 COUP 333 Preston Stre a ON K1S 5N4	u CA 11 eet Cana	Ida
Société II 30 Metcalfe Ottawa, On 613 998 77 IBI GR 400 – Ottawa tel 613	MMOBILIÈRE D Street Suite 60 K1P 5L4 77 COUP 333 Preston Stre	u CA 11 eet Cana	Ida
Socrétré II 30 Metcalfe Ottawa, On 613 998 77 IBI GR 400 – 3 Ottawa tel 613 ibigrou	Street Suite 60 K1P 5L4 77 COUP 333 Preston Stre a ON K1S 5N4 3 225 1311 fax 6	u CA 11 eet Cana	Ida
Société II 30 Metcalfe Ottawa, On 613 998 77 IBI GR 400 – Ottawa tel 613	MMOBILIÈRE D Street Suite 60 K1P 5L4 77 COUP 333 Preston Stre a ON K1S 5N4 3 225 1311 fax 6 up.com	eet Cana 313 23	ida 25 9868
Sociéré II 30 Metcalfe Ottawa, On 613 998 77 IBI GR 400 – 3 Ottawa tel 613 ibigrou Project Title WATERIC AT RO	Street Suite 60 K1P 5L4 77 COUP 333 Preston Stre a ON K1S 5N4 3 225 1311 fax 6 up.com	eet Cana 313 23	nda 25 9868
Sociéré II 30 Metcalfe Ottawa, On 613 998 77 IBI GR 400 – 3 Ottawa tel 613 ibigrou Project Title WATERID AT RO PH	Street Suite 60 K1P 5L4 77 COUP 333 Preston Stre a ON K1S 5N4 225 1311 fax 6 up.com	eet Cana 313 23	nda 25 9868
Sociéré II 30 Metcalfe Ottawa, On 613 998 77 IBI GR 400 – 3 Ottawa tel 613 ibigrou Project Title WATERIC AT RO	Street Suite 60 K1P 5L4 77 COUP 333 Preston Stre a ON K1S 5N4 3 225 1311 fax 6 up.com	eet Cana 313 23	nda 25 9868
Sociéré II 30 Metcalfe Ottawa, On 613 998 77 IBI GR 400 – 3 Ottawa tel 613 ibigrou Project Title WATERIC AT RO PH	Street Suite 60 K1P 5L4 77 COUP 333 Preston Stre a ON K1S 5N4 3 225 1311 fax 6 up.com OGE VIL CKCLIF HASE 1B	eet Cana 313 23	nda 25 9868
Sociéré II 30 Metcalfe Ottawa, On 613 998 77 IBI GR 400 – 3 Ottawa tel 613 ibigrou Project Title WATERID ATRO Pho Pho VATERID ATRO ATRO ATR	Street Suite 60 K1P 5L4 77 COUP 333 Preston Stre a ON K1S 5N4 3 225 1311 fax 6 up.com OGE VIL CKCLIF HASE 1B	eet Cana 313 23	nda 25 9868
Sociéré II 30 Metcalfe Ottawa, On 613 998 77 IBI GR 400 – 2 Ottawa tel 613 ibigrou Project Title WATERICA AT RO PH PH	Street Suite 60 K1P 5L4 77 COUP 333 Preston Stre a ON K1S 5N4 3 225 1311 fax 6 up.com OGE VIL CKCLIF HASE 1B	eet Cana 313 23	nda 25 9868
Sociéré II 30 Metcalfe Ottawa, On 613 998 77 IBI GR 400 – 3 Ottawa tel 613 ibigrou Project Title WATERID ATRO Pho Pho VATERID ATRO ATRO ATR	Street Suite 60 K1P 5L4 77 COUP 333 Preston Stre a ON K1S 5N4 3 225 1311 fax 6 up.com OGE VIL CKCLIF HASE 1B	eet Cana 313 23	nda 25 9868
Sociéré II 30 Metcalfe Ottawa, On 613 998 77 IBI GR 400 – 5 Ottawa tel 613 ibigrod Project Title WATERIE ADARES PH VORTESSION PH VORTESSION PH VORTESSION PH VORTESSION PH VORTESSION PH Drawing Title	AMOBILIÈRE DI Street Suite 60 K1P 5L4 77 COUP 333 Preston Stre a ON K1S 5N4 3 225 1311 fax 6 up.com OGE VIL CKCLIF HASE 1B	LA FE	Ida 25 9868
Sociéré II 30 Metcalfe Ottawa, On 613 998 77 BI GR 400 – 3 Ottawa tel 613 ibigrou Project Title WATERICA AT RO PH VATERICA AT RO PH	AMOBILIÈRE DI Street Suite 60 K1P 5L4 77 COUP 333 Preston Stre a ON K1S 5N4 3 225 1311 fax 6 up.com OGE VIL CKCLIF HASE 1B	LA FE	Ida 25 9868
Sociéré II 30 Metcalfe Ottawa, On 613 998 77 IBI GR 400 – 5 Ottawa tel 613 ibigrod Project Title WATERIE ADARES PH VORTESSION PH VORTESSION PH VORTESSION PH VORTESSION PH VORTESSION PH Drawing Title	AMOBILIÈRE DI Street Suite 60 K1P 5L4 77 COUP 333 Preston Stre a ON K1S 5N4 3 225 1311 fax 6 up.com OGE VIL CKCLIF HASE 1B	LA FE	Ida 25 9868
Sociéré II 30 Metcalfe Ottawa, On 613 998 77 IBI GR 400 – 5 Ottawa tel 613 ibigrod Project Title WATERIE ADARES PH VORTESSION PH VORTESSION PH VORTESSION PH VORTESSION PH VORTESSION PH Drawing Title	Street Suite 60 K1P 5L4 77 ROUP 333 Preston Stre a ON K1S 5N4 3 225 1311 fax 6 up.com	LA FE	Ida 25 9868
Sociéré II 30 Metcalfe Ottawa, On 613 998 77 IBI GR 400 – 5 Ottawa tel 613 ibigrod Project Title WATERIE ADARES PH VORTESSION PH VORTESSION PH VORTESSION PH VORTESSION PH VORTESSION PH Drawing Title	AMOBILIÈRE DI Street Suite 60 K1P 5L4 77 COUP 333 Preston Stre a ON K1S 5N4 3 225 1311 fax 6 up.com OGE VIL CKCLIF HASE 1B	LA FE	Ida 25 9868
Sociéré II 30 Metcalfe Ottawa, On 31 998 77 IBI GR 400 - 5 Ottawa Ottawa IBI GR 400 - 5 Ottawa Ottawa Variation Project Title VATERIZATION Project Title Drawing Title STREEET	Street Suite 60 K1P 5L4 77 COUP 333 Preston Stre a ON K1S 5N4 3 225 1311 fax 6 up.com OGE VIL CKCLIF HASE 1B SECTIC	LA FE	Inda 25 9868
EVALUATION CONTRACTOR OF CONTR	Street Suite 60 K1P 5L4 77 ROUP 333 Preston Stre a ON K1S 5N4 3 225 1311 fax 6 up.com OGE VIL CKCLIF HASE 1B SECTIC		Ada 25 9868 AGE S
Design	Street Suite 60 K1P 5L4 77 ROUP 333 Preston Stre a ON K1S 5N4 3 225 1311 fax 6 up.com OGE VIL CKCLIF HASE 1B SECTIC	LA FE	Ada 25 9868 AGE S