


ELECTRICAL SITE PLAN AND PHOTOMETRIC
SCALE: 1:150

Luminaire Schedule											
Symbol	Qty	Label	Arrangement	Description	LLF	Luminaire Lumens	Luminaire Watts	Total Watts	[MANUFAC]	Mounting Height	BUG Rating
	4	W	Single	TRP2-24L-30-3K7-3	0.900	3374	27.9	111.6	HUBBELL OUTDOOR	4.5	B1-U0-G1

Calculation Summary								
Label	CalcType	Units	Avg	Max	Min	Avg/Min	Max/Min	
Wall Mounts TYPE W	Illuminance	Fc	1.51	2.5	0.5	3.02	5.00	

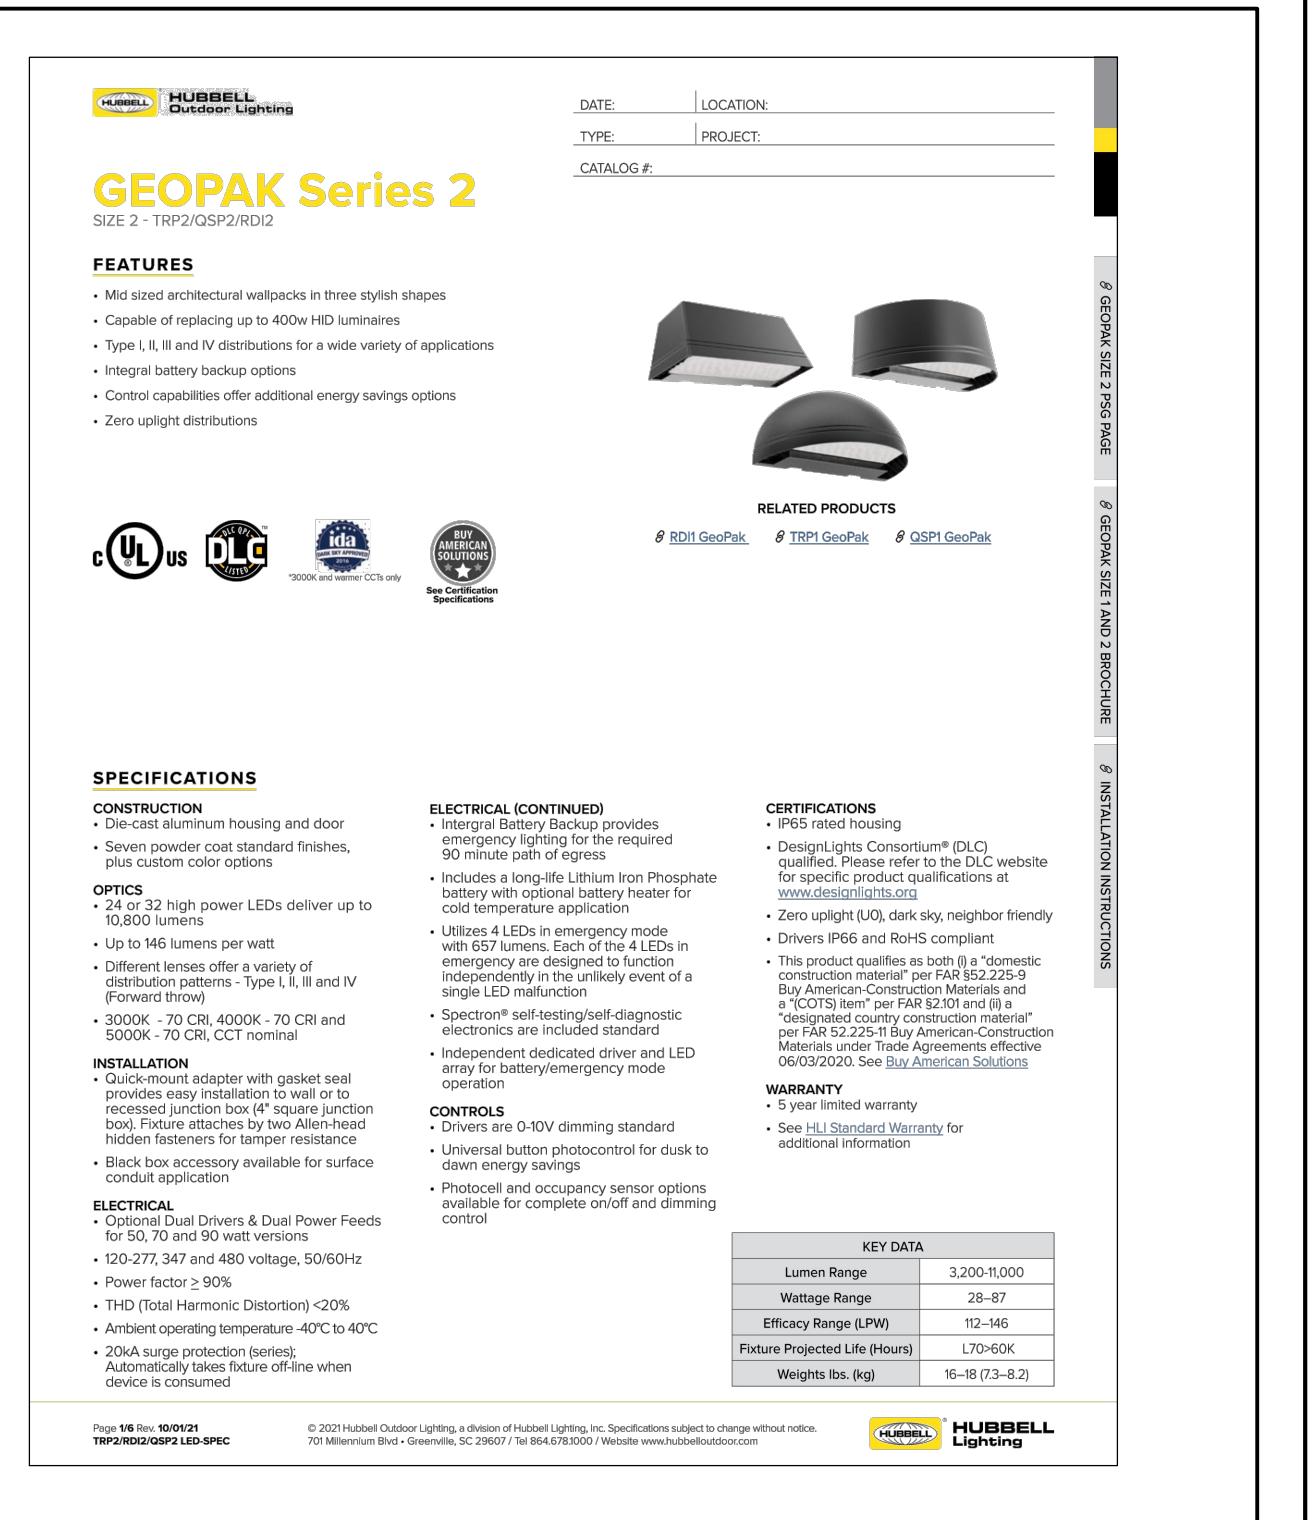

LUMINAIRE TYPE 'W'

SCALE: N.T.S.

THE SPECIFICATIONS ARE TO BE
CONSIDERED AS AN INTEGRAL PART OF
THESE DRAWINGS AND NEITHER THE
DRAWINGS NOR THE SPECIFICATIONS
SHALL BE USED ALONE. REFER TO
ARCHITECTURAL DRAWINGS FOR
DIMENSIONS. DO NOT SCALE.



FOR QUESTIONS REGARDING THIS PROJECT, PLEASE EMAIL:
S\NCR-22-@QUASARCG.COM

PROJECT

PROJECT

PROJECT

PROJECT

1592 TENTH LINE ROAD

OTTAWA

TITLE

ELECTRICAL SITE PLAN AND PHOTOMETRIC

ELECTRICAL CIRCUITS AND PHOTONETICS

CHECKED PROJECT No. **SNCR-22**

-- SINCER-22-

AS SHOWN E-001