



Drawing is not to scale. Contractor must check and verify all dimensions and conditions on the project, and must report any discrepancies to the consultants before proceeding with the work. The use of this drawing or part thereof is forbidden without the written approval of the consultants.

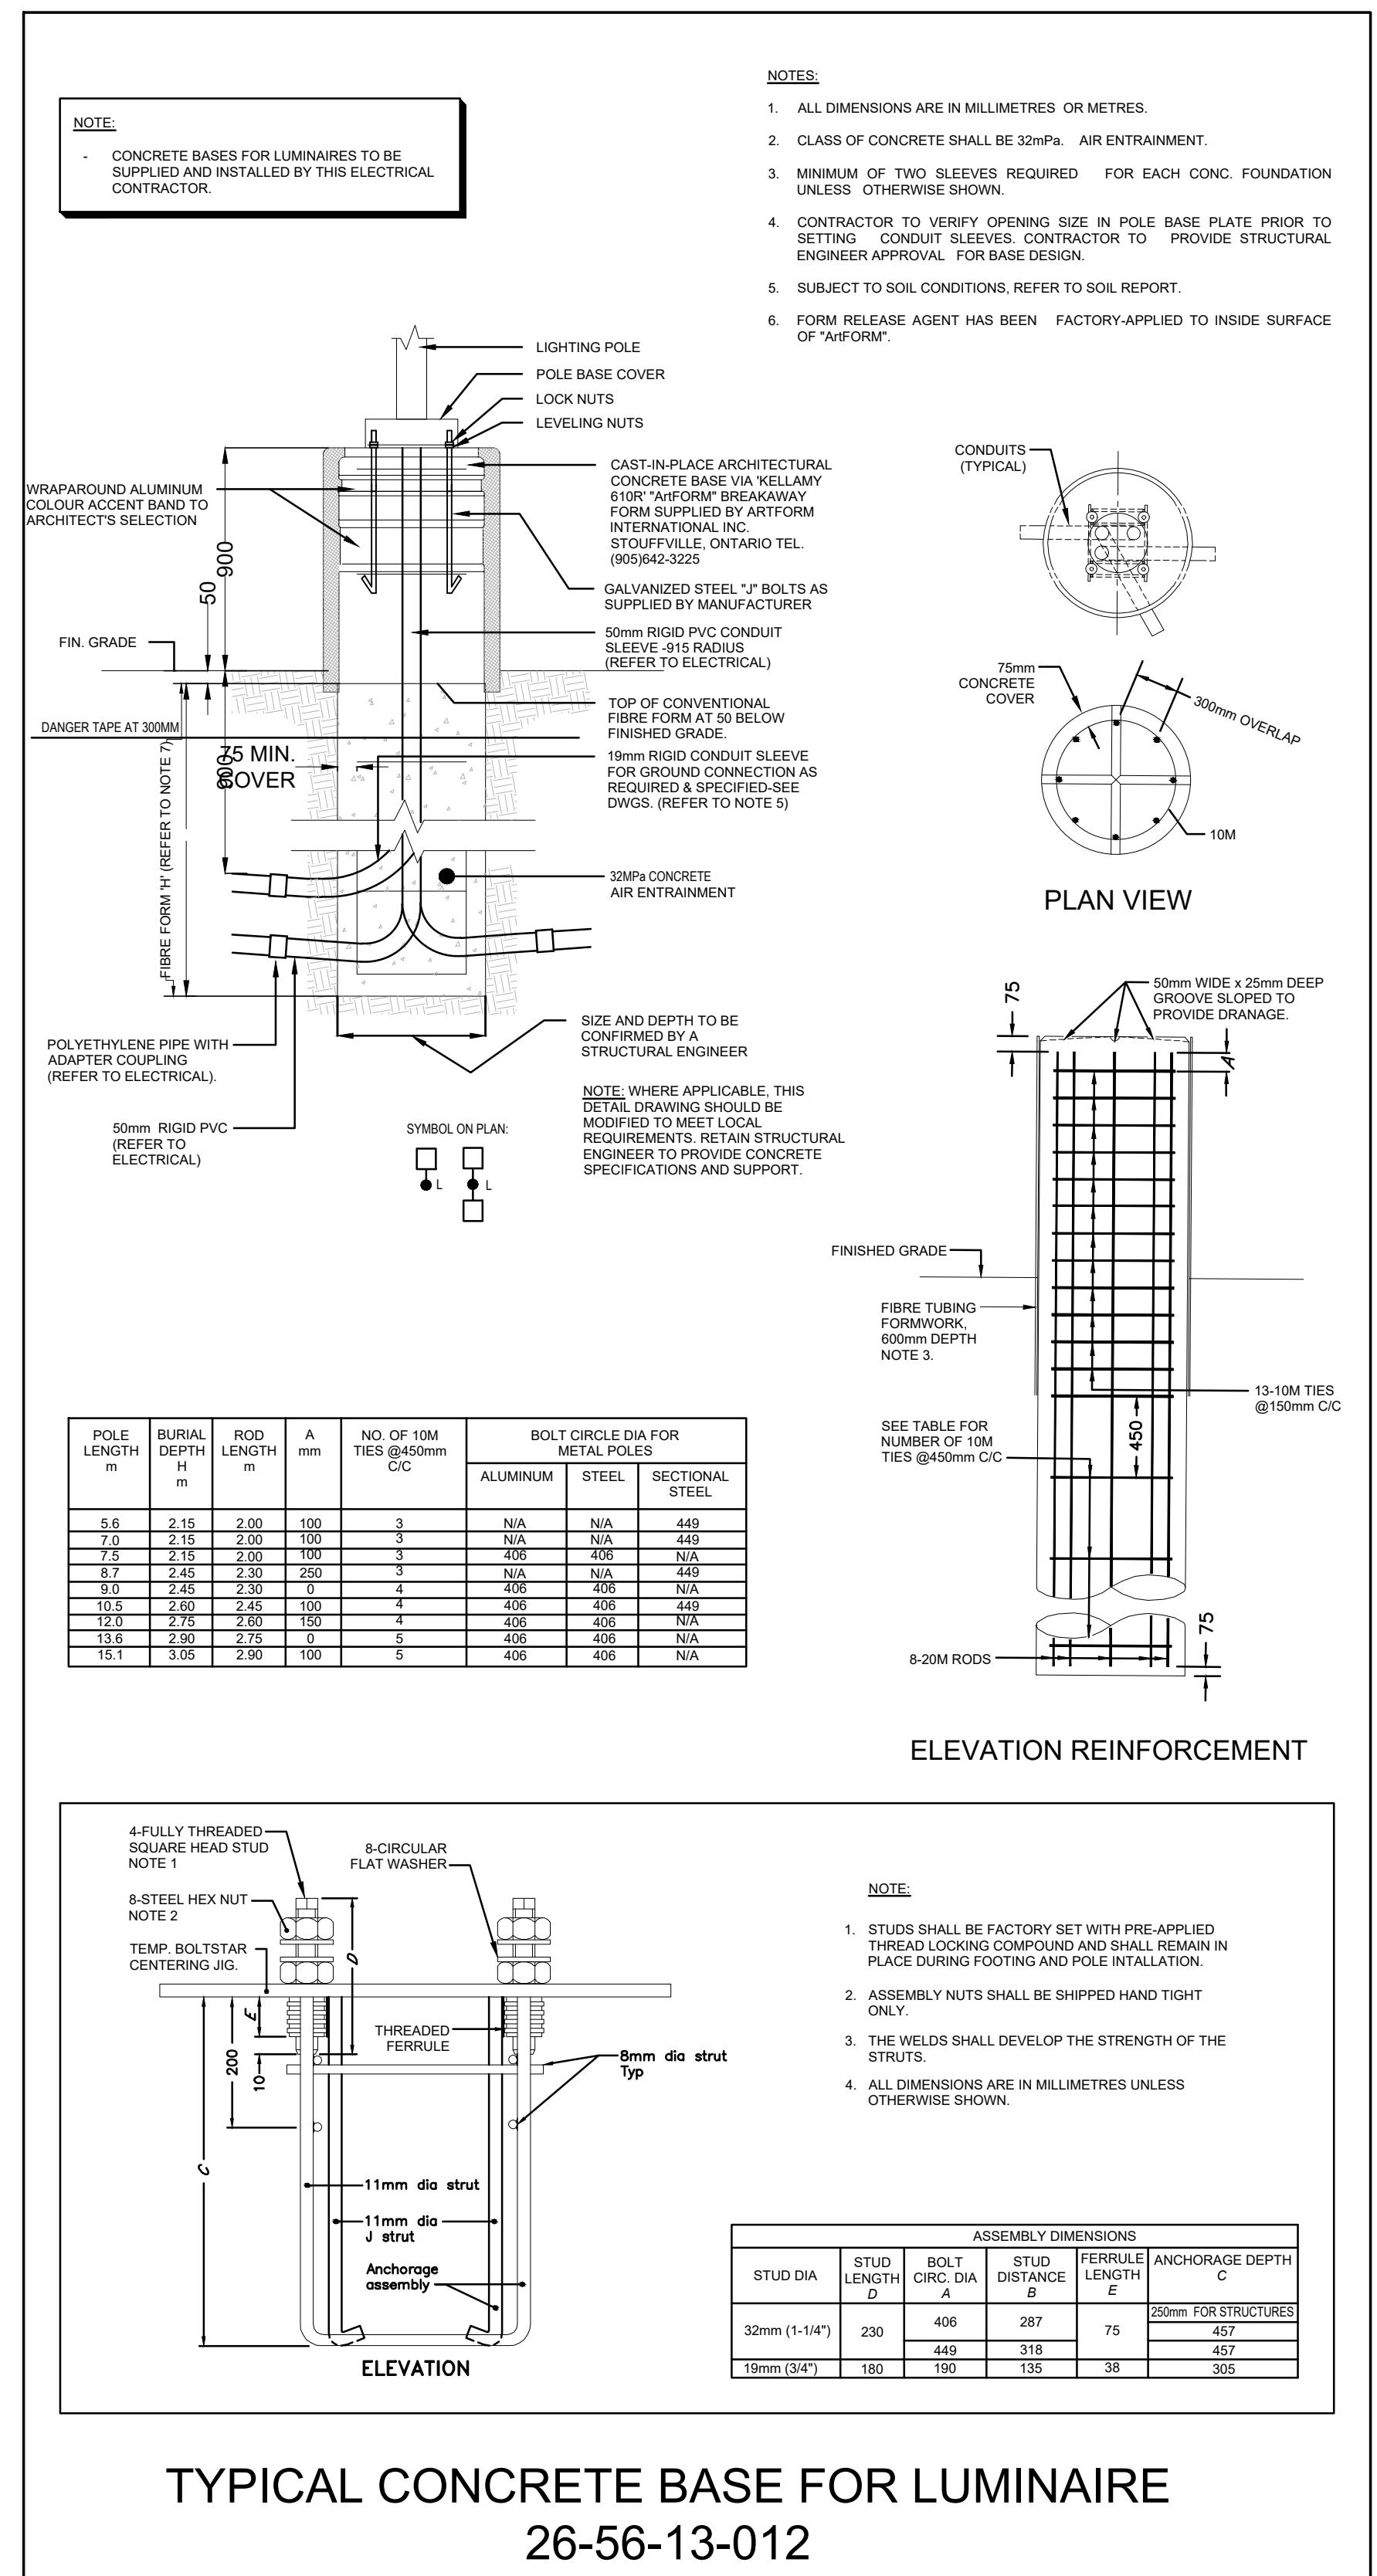

LIGHT FIXTURE SCHEDULE	
TYPE	DESCRIPTION
AALL	LUMINAIRE/POLE ASSEMBLY CONSISTING OF A DOUBLE (2) LED LUMINAIRES WITH AN AREA ROUND DISTRIBUTION PATTERN, 347V OUTDOOR USE BALLAST ON A 30"-0" SQUARE STEEL POLE WITH POLE BASE COVER ON 36" CONCRETE BASE. COLOUR OF FINISH OF POLE/HEAD TO ARCHITECT/OWNER SELECTION. LAMPS SHALL BE SUPPLIED WITH THE FIXTURE. FIXTURE TO HAVE FLAT LENS AND BE FULL CUT OFF. FIXTURE TO BE C/W HOUSE SIDE SHIELD. COOPER GALLEON SERIES GLEON-SA7-C-740-9-5WQ-QM-XX
BBLL	LUMINAIRE/POLE ASSEMBLY CONSISTING OF A SINGLE (1) LED LUMINAIRE WITH A TYPE III DISTRIBUTION PATTERN, 347V OUTDOOR USE BALLAST ON A 30"-0" SQUARE STEEL POLE WITH POLE BASE COVER ON 36" CONCRETE BASE. COLOUR OF FINISH OF POLE/HEAD TO ARCHITECT/OWNER SELECTION. LAMPS SHALL BE SUPPLIED WITH THE FIXTURE. FIXTURE TO HAVE FLAT LENS AND BE FULL CUT OFF. FIXTURE TO BE C/W HOUSE SIDE SHIELD. COOPER GALLEON SERIES GLEON-SA7-C-740-9-73M-XX-HSS
CCLL	LUMINAIRE/POLE ASSEMBLY CONSISTING OF A SINGLE (1) LED LUMINAIRE WITH A TYPE IV DISTRIBUTION PATTERN, 347V OUTDOOR USE BALLAST ON A 30"-0" SQUARE STEEL POLE WITH POLE BASE COVER ON 36" CONCRETE BASE. COLOUR OF FINISH OF POLE/HEAD TO ARCHITECT/OWNER SELECTION. LAMPS SHALL BE SUPPLIED WITH THE FIXTURE. FIXTURE TO HAVE FLAT LENS AND BE FULL CUT OFF. FIXTURE TO BE C/W HOUSE SIDE SHIELD. COOPER GALLEON SERIES GLEON-SA7-C-740-9-T4-QM-XX-HSS

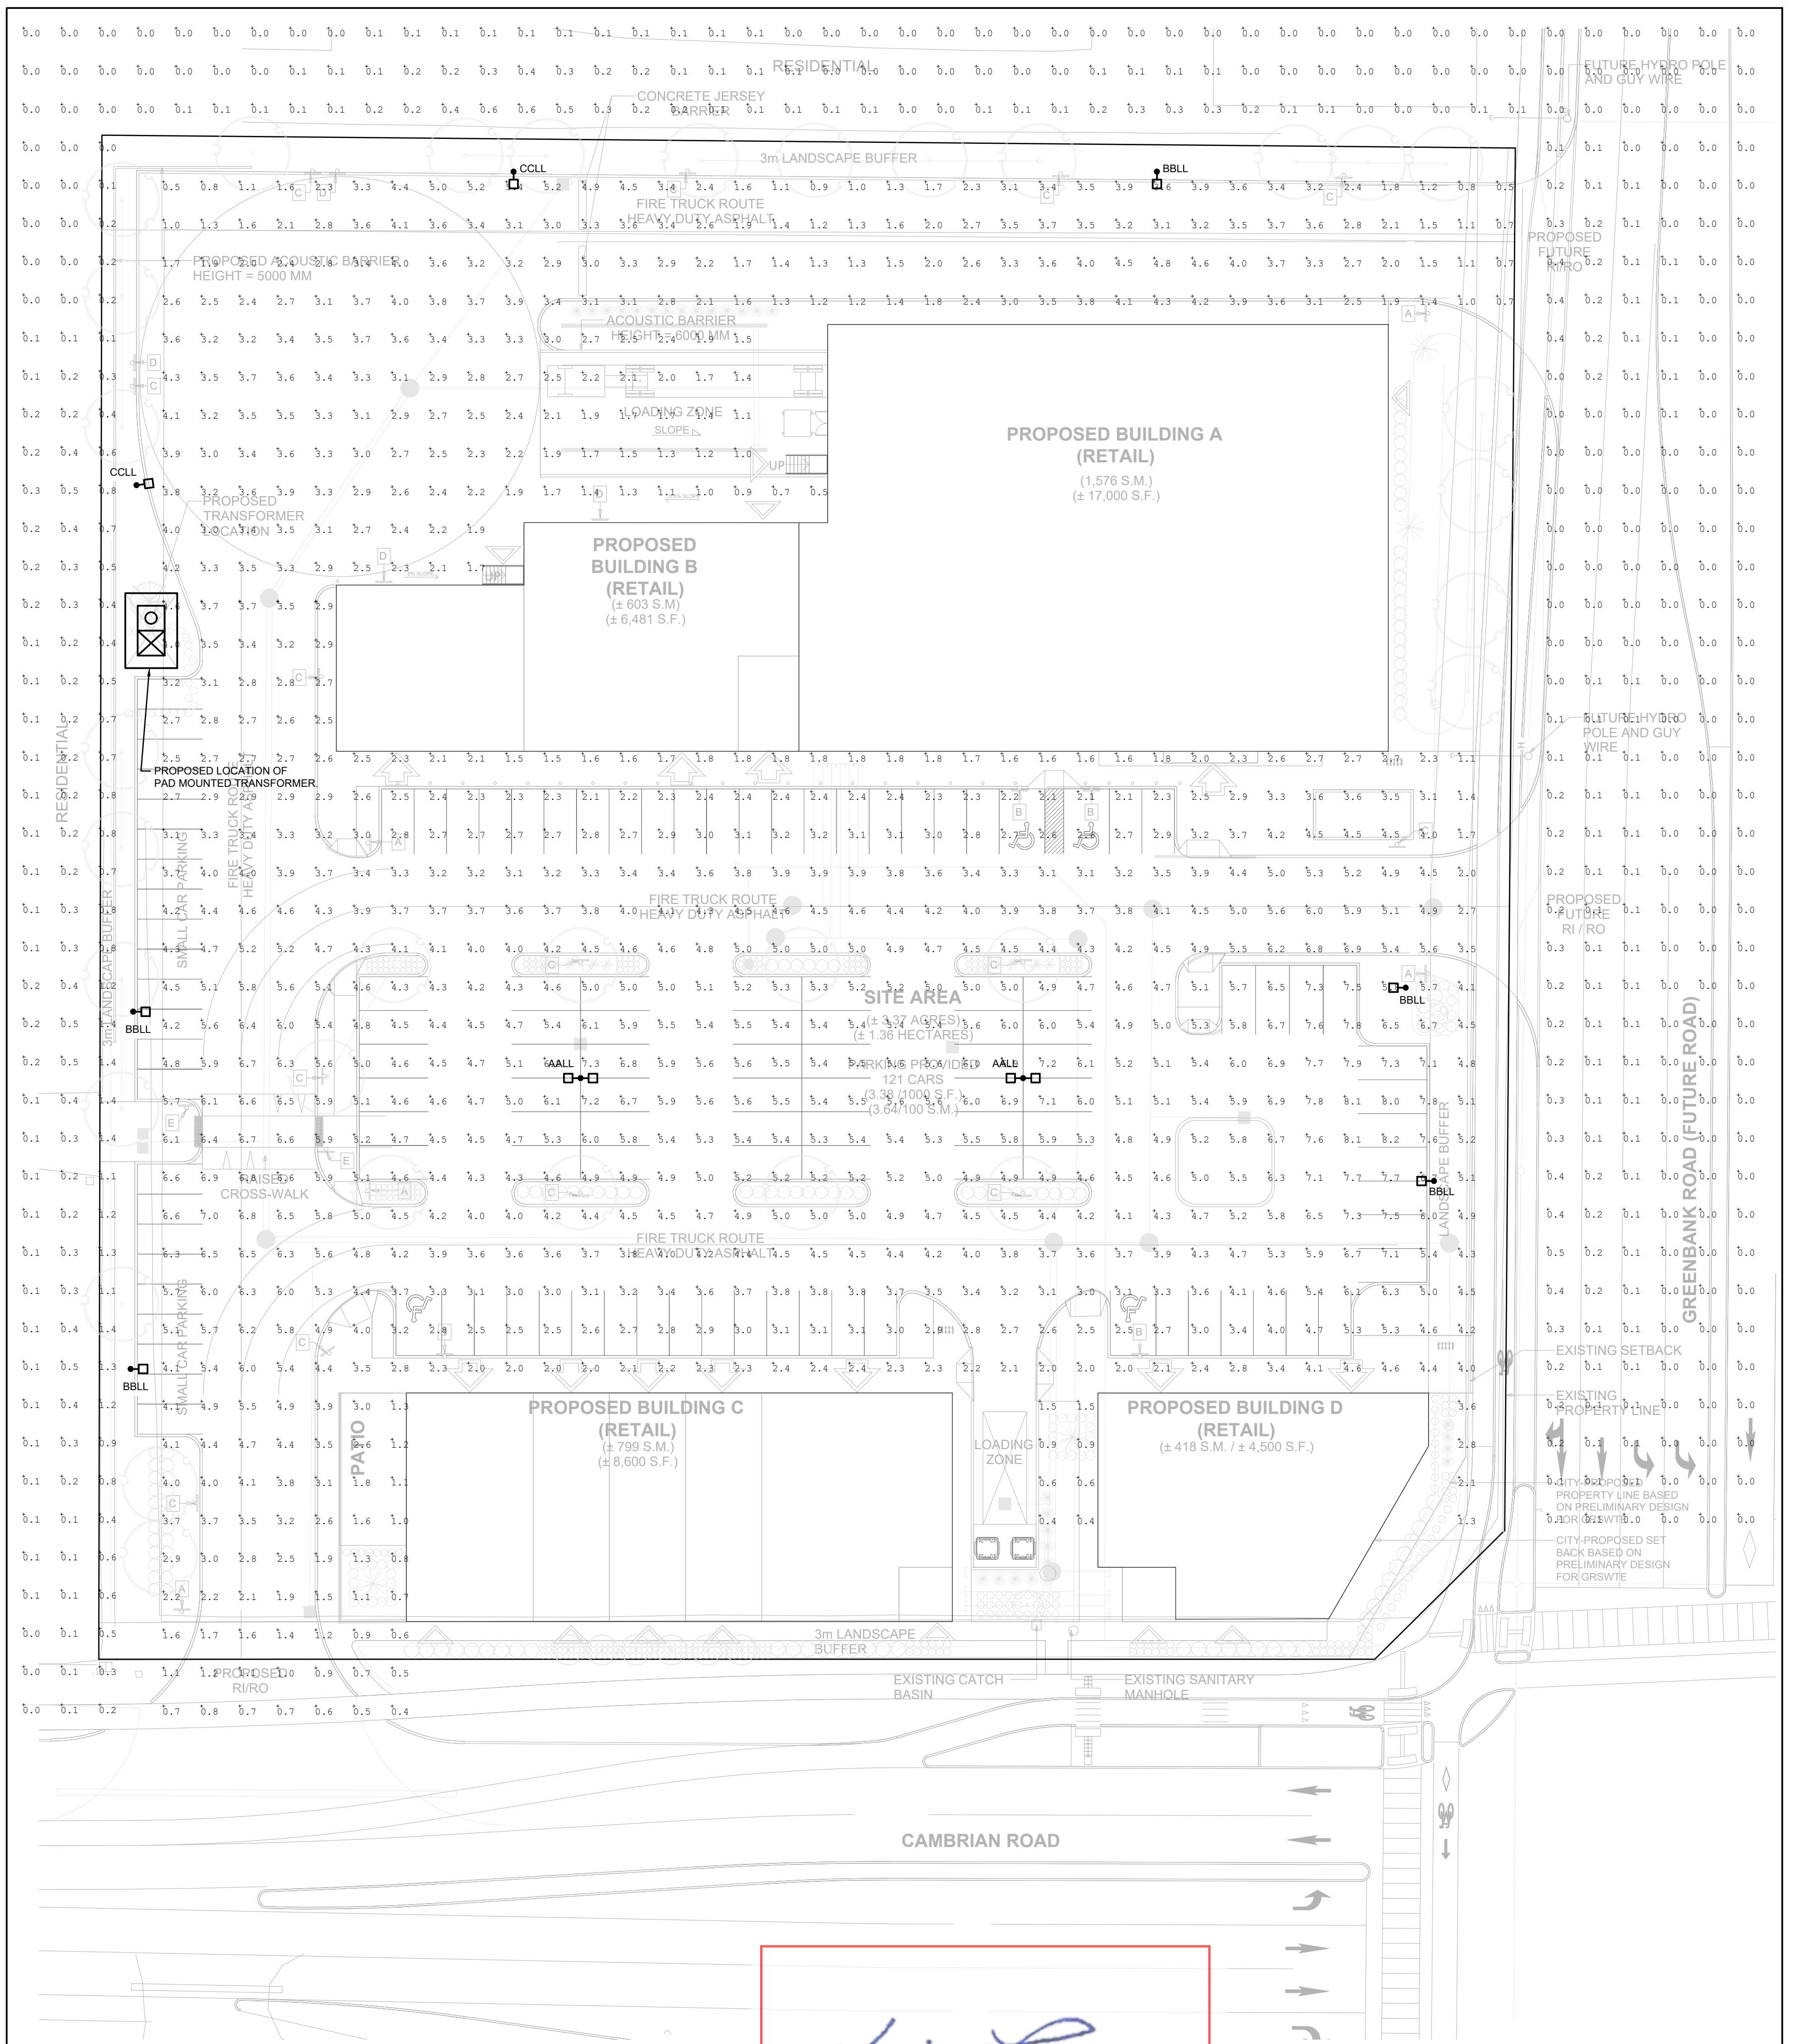

Choice Properties RETAIL

PROJECT	CAMBRIAN RD (N. PARCEL)	
BARRHAVEN, ONTARIO		
DRAWING		
ELECTRICAL PHOTOMETRIC SITE PLAN		
PROJECT NO.	22-013-006	
PROJECT DATE	2022-11-02	
DRAWN BY	BD	
CHECKED BY	BK	
SCALE	AS NOTED	
DRAWING NO.	ESP	REV.

[Handwritten signature]

PROFESSIONAL ENGINEERS
REGISTRATION BOARD
2024-02-B
M. HAMMERSCHLAG
22-013-006