


# SOUTH MARCH BESS CIVIL PACKAGE

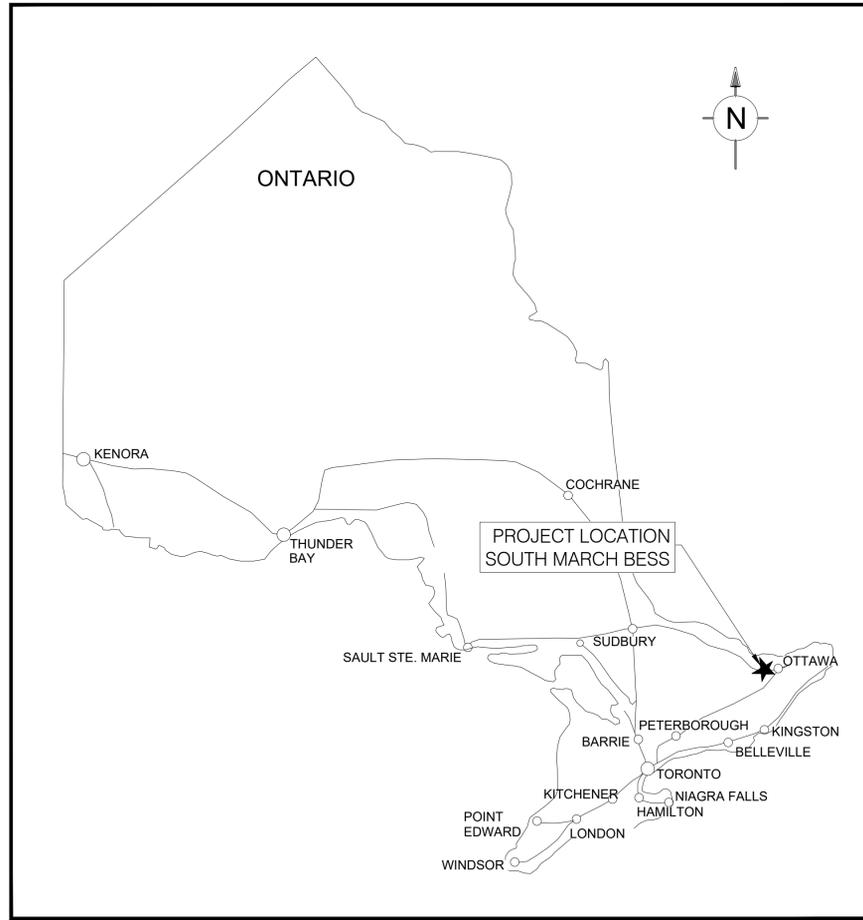

**KEY PLAN**  
SCALE: NTS

DRAWING INDEX				
BBA DRAWING NO.	REV.	DATE	CATEGORY	SHEET DESCRIPTION
7154023-100000-41-D01-0002	AK	2026-01-23	GENERAL	GENERAL NOTES, LEGEND AND ABBREVIATIONS
7154023-100000-41-D20-0001-01	AI	2026-01-29	PLAN	SITE PLAN - SHEET 1
7154023-100000-41-D20-0001-02	AN	2026-02-06	PLAN	SITE PLAN - SHEET 2
7154023-100000-41-D20-0003	AF	2026-01-23	PLAN	SITE SERVICING AND FIRE PROTECTION PLAN
7154023-100000-41-D20-0004	AD	2026-01-23	PLAN & SECTIONS	WET POND
7154023-100000-41-D20-0005	AF	2026-01-23	PLAN	ROAD & FINISHED GRADE
7154023-100000-41-D20-0006	AD	2026-01-23	PROFILES	SITE GRADING
7154023-100000-41-D20-0007	AA	2026-01-23	PLAN	SETBACK FROM EXISTING RESIDENCES
7154023-100000-41-D30-0001	AA	2026-01-23	PLAN	PRE-DEVELOPMENT SUB-CATCHMENT AREAS
7154023-100000-41-D30-0002	AA	2026-11-05	PLAN	POST-DEVELOPMENT SUB-CATCHMENT AREAS
7154023-100000-41-D50-0001	AD	2025-11-05	DETAILS	STORMWATER AND WATER NETWORK
7154023-100000-41-D50-0002	AD	2026-01-23	DETAILS	ROAD AND DRAINAGE DETAILS
7154023-100000-41-D52-0001	AB	2026-01-23	PLAN	ROADS AND DITCHES , KEY PLAN
7154023-100000-41-D52-0002	AB	2026-01-23	PROFILES	ROADS AND DITCHES PROFILES
7154023-100000-41-D52-0003	AC	2026-01-29	PROFILES	ROADS AND DITCHES PROFILES
7154023-100000-41-D70-0001-01	AF	2026-01-23	PLAN	EROSION AND SEDIMENT CONTROL
7154023-100000-41-D70-0002-02	AA	2026-01-23	PLAN	EROSION AND SEDIMENT CONTROL
7154023-100000-41-D70-0003-03	AA	2026-01-23	PLAN	EROSION AND SEDIMENT CONTROL
7154023-100000-41-D70-0004-04	AA	2026-01-23	PLAN	EROSION AND SEDIMENT CONTROL
7154023-100000-41-D70-0005-05	AA	2026-01-23	PLAN	EROSION AND SEDIMENT CONTROL
7154023-100000-41-D70-0006-06	AA	2026-01-23	PLAN	EROSION AND SEDIMENT CONTROL
7154023-100000-41-D70-0002	AD	2026-11-05	DETAILS	EROSION AND SEDIMENT CONTROL
7154023-100000-41-D90-0001	AC	2025-11-05	STANDARD DETAILS	SECURITY FENCING

**FOR PERMITTING**

DRAWING No.	DESCRIPTION	REV	DESCRIPTION	VERIFIED BY	APPROVED BY	DATE																																																	
<table border="1" style="width: 100%; border-collapse: collapse;"> <tr> <td style="width: 20%;">ENVIRONMENTAL-STANTEC.DWG</td> <td style="width: 30%;">AF</td> <td style="width: 10%;">FOR PERMITTING</td> <td style="width: 10%;">B. THOMAS</td> <td style="width: 10%;">V. BRUNELLE</td> <td style="width: 10%;">P.E.O NO. 100617887</td> <td style="width: 10%;">2026-02-06</td> </tr> <tr> <td>XR-16042040-L-PLANTING.DWG</td> <td>AG</td> <td>FOR PERMITTING</td> <td>B. THOMAS</td> <td>V. BRUNELLE</td> <td>P.E.O NO. 100617887</td> <td>2026-01-29</td> </tr> <tr> <td>241451-SouthMarch_BESS-MTMS-Rev0</td> <td>AF</td> <td>FOR PERMITTING</td> <td>B. THOMAS</td> <td>V. BRUNELLE</td> <td>P.E.O NO. 100617887</td> <td>2026-01-23</td> </tr> <tr> <td>SOUTH MARCH DITCH LINE TOPO</td> <td>AE</td> <td>FOR PERMITTING</td> <td>B. THOMAS</td> <td>V. BRUNELLE</td> <td>P.E.O NO. 100617887</td> <td>2025-11-07</td> </tr> <tr> <td>SOUTH MARCH BESS-250 MW 230KV-34.5 KV SUBSTATION</td> <td>AD</td> <td>FOR PERMITTING</td> <td>E. AMELI</td> <td>M. SHAHRAKI</td> <td>P.E.O NO. 100617887</td> <td>2025-11-05</td> </tr> <tr> <td></td> <td>AC</td> <td>FOR PERMITTING</td> <td>E. AMELI</td> <td>M. SHAHRAKI</td> <td>P.E.O NO. 100617887</td> <td>2025-06-19</td> </tr> <tr> <td></td> <td>AB</td> <td>FOR COMMENTS</td> <td>E. AMELI</td> <td>M. SHAHRAKI</td> <td>P.E.O NO. 100617887</td> <td>2025-06-04</td> </tr> </table>							ENVIRONMENTAL-STANTEC.DWG	AF	FOR PERMITTING	B. THOMAS	V. BRUNELLE	P.E.O NO. 100617887	2026-02-06	XR-16042040-L-PLANTING.DWG	AG	FOR PERMITTING	B. THOMAS	V. BRUNELLE	P.E.O NO. 100617887	2026-01-29	241451-SouthMarch_BESS-MTMS-Rev0	AF	FOR PERMITTING	B. THOMAS	V. BRUNELLE	P.E.O NO. 100617887	2026-01-23	SOUTH MARCH DITCH LINE TOPO	AE	FOR PERMITTING	B. THOMAS	V. BRUNELLE	P.E.O NO. 100617887	2025-11-07	SOUTH MARCH BESS-250 MW 230KV-34.5 KV SUBSTATION	AD	FOR PERMITTING	E. AMELI	M. SHAHRAKI	P.E.O NO. 100617887	2025-11-05		AC	FOR PERMITTING	E. AMELI	M. SHAHRAKI	P.E.O NO. 100617887	2025-06-19		AB	FOR COMMENTS	E. AMELI	M. SHAHRAKI	P.E.O NO. 100617887	2025-06-04
ENVIRONMENTAL-STANTEC.DWG	AF	FOR PERMITTING	B. THOMAS	V. BRUNELLE	P.E.O NO. 100617887	2026-02-06																																																	
XR-16042040-L-PLANTING.DWG	AG	FOR PERMITTING	B. THOMAS	V. BRUNELLE	P.E.O NO. 100617887	2026-01-29																																																	
241451-SouthMarch_BESS-MTMS-Rev0	AF	FOR PERMITTING	B. THOMAS	V. BRUNELLE	P.E.O NO. 100617887	2026-01-23																																																	
SOUTH MARCH DITCH LINE TOPO	AE	FOR PERMITTING	B. THOMAS	V. BRUNELLE	P.E.O NO. 100617887	2025-11-07																																																	
SOUTH MARCH BESS-250 MW 230KV-34.5 KV SUBSTATION	AD	FOR PERMITTING	E. AMELI	M. SHAHRAKI	P.E.O NO. 100617887	2025-11-05																																																	
	AC	FOR PERMITTING	E. AMELI	M. SHAHRAKI	P.E.O NO. 100617887	2025-06-19																																																	
	AB	FOR COMMENTS	E. AMELI	M. SHAHRAKI	P.E.O NO. 100617887	2025-06-04																																																	
REFERENCE DRAWINGS				REVISIONS																																																			

  <small>by Brookfield Renewable</small>	<p>APPLICATION FILE NUMBER : 007-12-25-0096 PLAN NUMBER : 19401</p> <p>PROJECT: <b>SOUTH MARCH BESS</b> <b>2555 AND 2625 MARCHURST RD, OTTAWA</b></p> <p>TITLE: <b>GENERAL</b> <b>CIVIL COVER PAGE &amp; DRAWING INDEX</b></p> <table style="width: 100%; border: none;"> <tr> <td style="width: 50%; border: none;">                 DESIGNED BY: B. THOMAS VERIFIED BY: V. BRUNELLE SCALE: N/A             </td> <td style="width: 50%; border: none;">                 DRAFTED BY: G. NORMAND APPROVED BY: V. BRUNELLE DATE: 2025-03-07             </td> </tr> </table> <p>DRAWING No.: <b>7154023-100000-41-D01-0001</b>    SHEET: <b>01</b>    SIZE: <b>A1</b>    REV: <b>AI</b></p>	DESIGNED BY: B. THOMAS VERIFIED BY: V. BRUNELLE SCALE: N/A	DRAFTED BY: G. NORMAND APPROVED BY: V. BRUNELLE DATE: 2025-03-07
DESIGNED BY: B. THOMAS VERIFIED BY: V. BRUNELLE SCALE: N/A	DRAFTED BY: G. NORMAND APPROVED BY: V. BRUNELLE DATE: 2025-03-07		

BY: M. SHARAFI, G. NORMAND  
PRINTED: 2025-02-26 09:52:58