


SOUTH MARCH BESS CIVIL PACKAGE

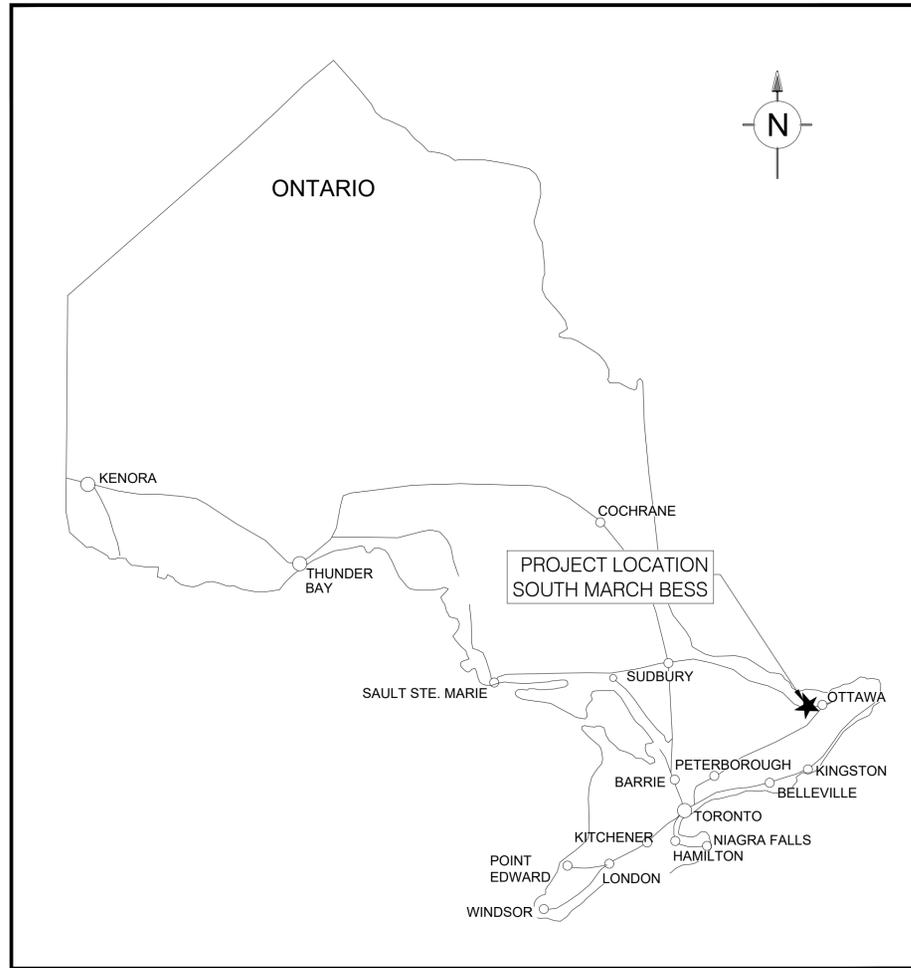

KEY PLAN
SCALE: NTS

DRAWING INDEX				
BBA DRAWING NO.	REV.	DATE	CATEGORY	SHEET DESCRIPTION
7154023-100000-41-D01-0002	AD	2025-11-05	GENERAL	GENERAL NOTES, LEGEND AND ABBREVIATIONS
7154023-100000-41-D20-0001-01	AI	2026-01-29	PLAN	SITE PLAN - SHEET 1
7154023-100000-41-D20-0001-02	AN	2026-02-06	PLAN	SITE PLAN - SHEET 2
7154023-100000-41-D20-0003	AF	2026-01-23	PLAN	SITE SERVICING AND FIRE PROTECTION PLAN
7154023-100000-41-D20-0004	AD	2026-01-23	PLAN & SECTIONS	WET POND
7154023-100000-41-D20-0005	AE	2026-01-23	PLAN	ROAD & FINISHED GRADE
7154023-100000-41-D20-0006	AD	2026-01-23	PROFILES	SITE GRADING
7154023-100000-41-D20-0007	AA	2025-11-05	PLAN	SETBACK FROM EXISTING RESIDENCES
7154023-100000-41-D30-0001	AA	2026-01-23	PLAN	PRE-DEVELOPMENT SUB-CATCHMENT AREAS
7154023-100000-41-D30-0002	AA	2026-01-23	PLAN	POST-DEVELOPMENT SUB-CATCHMENT AREAS
7154023-100000-41-D50-0001	AD	2025-11-05	DETAILS	STORMWATER AND WATER NETWORK
7154023-100000-41-D50-0002	AD	2026-01-23	DETAILS	ROAD AND DRAINAGE DETAILS
7154023-100000-41-D52-0001	AB	2026-01-23	PLAN	ROADS AND DITCHES , KEY PLAN
7154023-100000-41-D52-0002	AB	2026-01-23	PROFILES	ROADS AND DITCHES PROFILES
7154023-100000-41-D52-0003	AC	2026-01-29	PROFILES	ROADS AND DITCHES PROFILES
7154023-100000-41-D70-0001-01	AA	2026-01-23	PLAN	EROSION AND SEDIMENT CONTROL
7154023-100000-41-D70-0002-02	AA	2026-01-23	PLAN	EROSION AND SEDIMENT CONTROL
7154023-100000-41-D70-0003-03	AA	2026-01-23	PLAN	EROSION AND SEDIMENT CONTROL
7154023-100000-41-D70-0004-04	AA	2026-01-23	PLAN	EROSION AND SEDIMENT CONTROL
7154023-100000-41-D70-0005-05	AA	2026-01-23	PLAN	EROSION AND SEDIMENT CONTROL
7154023-100000-41-D70-0006-06	AA	2026-01-23	PLAN	EROSION AND SEDIMENT CONTROL
7154023-100000-41-D70-0002	AD	2026-11-05	DETAILS	EROSION AND SEDIMENT CONTROL
7154023-100000-41-D90-0001	AC	2025-11-05	STANDARD DETAILS	SECURITY FENCING

FOR PERMITTING

DRAWING No.	DESCRIPTION	REV	DESCRIPTION	VERIFIED BY	APPROVED BY	DATE
		AJ	FOR PERMITTING	B. THOMAS	V. BRUNELLE	2026-02-19
		AI	FOR PERMITTING	B. THOMAS	V. BRUNELLE	2026-02-06
		AH	FOR PERMITTING	B. THOMAS	V. BRUNELLE	2026-01-29
	ENVIRONMENTAL-STANTEC.DWG	AG	FOR PERMITTING	B. THOMAS	V. BRUNELLE	2026-01-23
	XR-160402040-L-PLANTING.DWG	AF	FOR PERMITTING	B. THOMAS	V. BRUNELLE	2025-11-07
	241451-SouthMarch_BESS-MTM9-Rev0	AE	FOR PERMITTING	B. THOMAS	V. BRUNELLE	2025-11-05
	SOUTH MARCH DITCH LINE TOPO	AD	FOR PERMITTING	E. AMELI	M. SHAHRAKI	2025-07-03
7154023-402000-47-D20-0001	SOUTH MARCH BESS-250 MW 230KV-34.5 kV SUBSTATION	AC	FOR PERMITTING	E. AMELI	M. SHAHRAKI	2025-06-19
		REV	DESCRIPTION	VERIFIED BY	APPROVED BY	DATE

REV	DESCRIPTION	VERIFIED BY	APPROVED BY	DATE
AJ	FOR PERMITTING	B. THOMAS	V. BRUNELLE	2026-02-19
AI	FOR PERMITTING	B. THOMAS	V. BRUNELLE	2026-02-06
AH	FOR PERMITTING	B. THOMAS	V. BRUNELLE	2026-01-29
AG	FOR PERMITTING	B. THOMAS	V. BRUNELLE	2026-01-23
AF	FOR PERMITTING	B. THOMAS	V. BRUNELLE	2025-11-07
AE	FOR PERMITTING	B. THOMAS	V. BRUNELLE	2025-11-05
AD	FOR PERMITTING	E. AMELI	M. SHAHRAKI	2025-07-03
AC	FOR PERMITTING	E. AMELI	M. SHAHRAKI	2025-06-19

APPLICATION FILE NUMBER : D07-12-25-0096
PLAN NUMBER : 19401

Evolgen

by Brookfield Renewable

PROJECT: SOUTH MARCH BESS 2555 AND 2625 MARCHURST RD, OTTAWA	
TITLE: GENERAL CIVIL COVER PAGE & DRAWING INDEX	
CLIENT:	DESIGNED BY: B. THOMAS
VERIFIED BY: V. BRUNELLE	DRAFTED BY: G. NORMAND
SCALE: N/A	APPROVED BY: V. BRUNELLE
DRAWING No.: 7154023-100000-41-D01-0001	DATE: 2025-03-07
SHEET: 01	SIZE: A1
REV.: AJ	