



5 GRAVEL MAINTENANCE BAND AT TOWER A CW-02
SCALE 1 : 10
TYPICAL SECTION

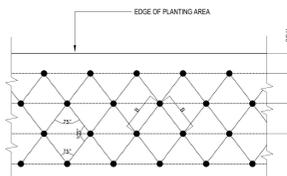


TRIANGULAR SPACING = B	DISTANCE BETWEEN ROWS = H	TOTAL AREA (SF) PER PLANT
6"	5"	0.21
8"	7"	0.39
9"	8"	0.50
10"	8 1/2"	0.59
12"	10 1/2"	0.88
15"	13"	1.35
18"	15 1/2"	1.94
21"	18"	2.63
24" (2')	21"	3.50
30"	26"	5.42


4 TRIANGULAR PLANTING SPACING DIAGRAM
REFERENCES

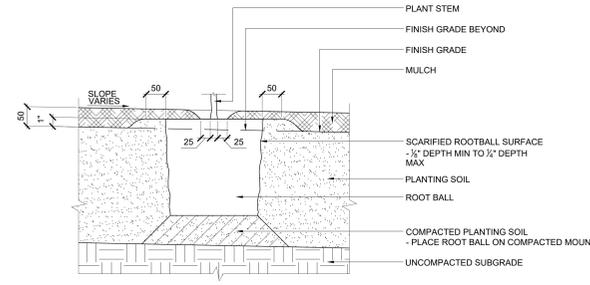

3 SHRUB PLANTING
SCALE 1 : 5
SECTION

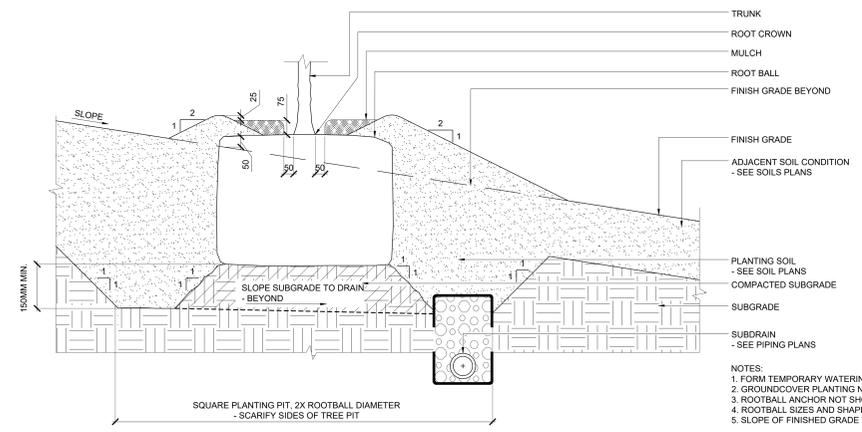

2 TREE PLANTING ON SLOPE
SCALE 1 : 10
SECTION

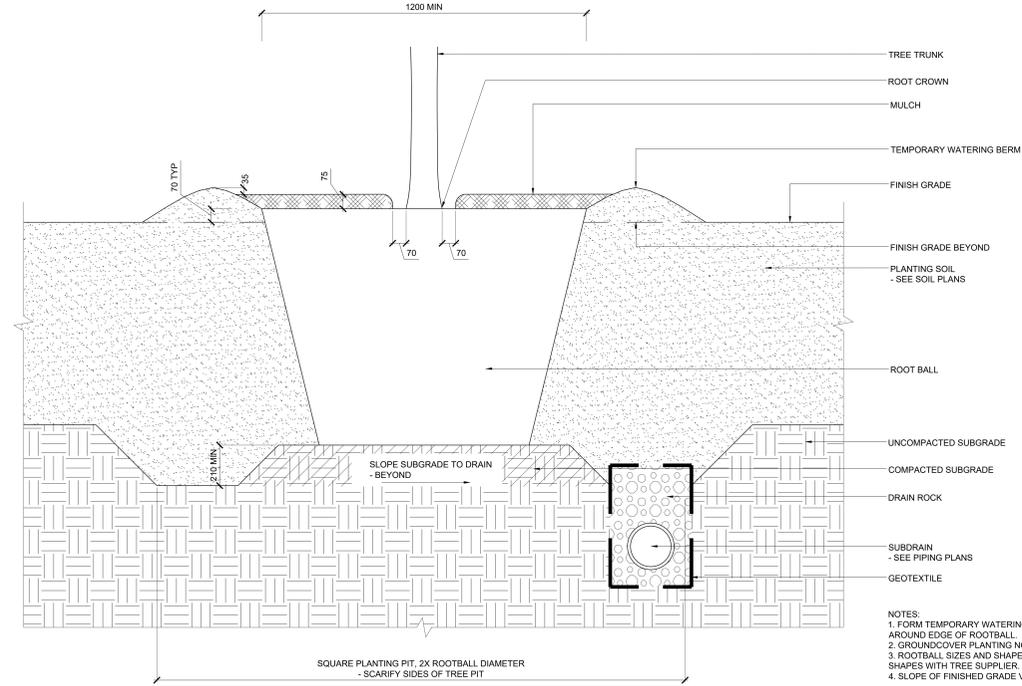

1 TREE PLANTING
SCALE 1 : 10
SECTION

KEY PLAN

THIS DRAWING TO BE PRINTED IN COLOUR.

REVISIONS

NO.	DESCRIPTION	DATE
01	ACFOR READINESS	2025-01-09
02	35% DD SUBMISSION	2025-01-29
03	65% DD SUBMISSION	2025-06-09
04	SITE PLAN CONTROL, RESUBMISSION	2025-08-05
05	65% DD SUBMISSION	2025-09-19
06	SITE PLAN CONTROL, RESUBMISSION	2025-01-13
07	65% DD SUBMISSION	2025-09-19

DRAWING STATUS

NOT FOR CONSTRUCTION

DISCREPANCIES MUST BE REPORTED IMMEDIATELY TO THE ARCHITECT BEFORE PROCEEDING. ONLY FIGURED DIMENSIONS ARE TO BE USED. CONTRACTORS MUST CHECK ALL DIMENSIONS ON SITE. THIS DRAWING IS PROTECTED BY COPYRIGHT.

ALL DIMENSIONS ARE SHOWN IN METRIC.

AUTHOR



PROJECT TEAM

DESIGN/BUILDER POLED, A JOINT VENTURE

ARCHITECTURAL PARRON ARCHITECTS LIMITED, ZOOHL LAMARIE PRATTE ARCHITECTES, ADAMSON ASSOCIATE ARCHITECTS, 888 ARCHITECTS INC.

STRUCTURAL STEPHENSON ENGINEERING LTD, BOUTHILLET PARIZEAU INC.

MECHANICAL HJI ANGUS & ASSOCIATES LTD, CROSEY ENGINEERING LTD.

ELECTRICAL MELVEY & BIRNAN INTERNATIONAL INC.

CIVIL HEP O'NEILL INC.

LANDSCAPE HERSCHELS DESIGN INC, PWP LANDSCAPE ARCHITECTURE

BUILDING CODE UMG BUILDING CODE CONSULTANTS LTD.

AUTHOR PROJECT NO.
PCL2301_C

DRAWING TITLE
PLANTING DETAILS

DRAWN	CHECKED

SCALE AT 40" x 60" DATE 06-JAN-2025
AS NOTED

GRAPHIC SCALE AS NOTED