



PLOT DATE: 05/26/2025 10:58:15 AM CUSTOMER SHEET SIZE: 1189x842

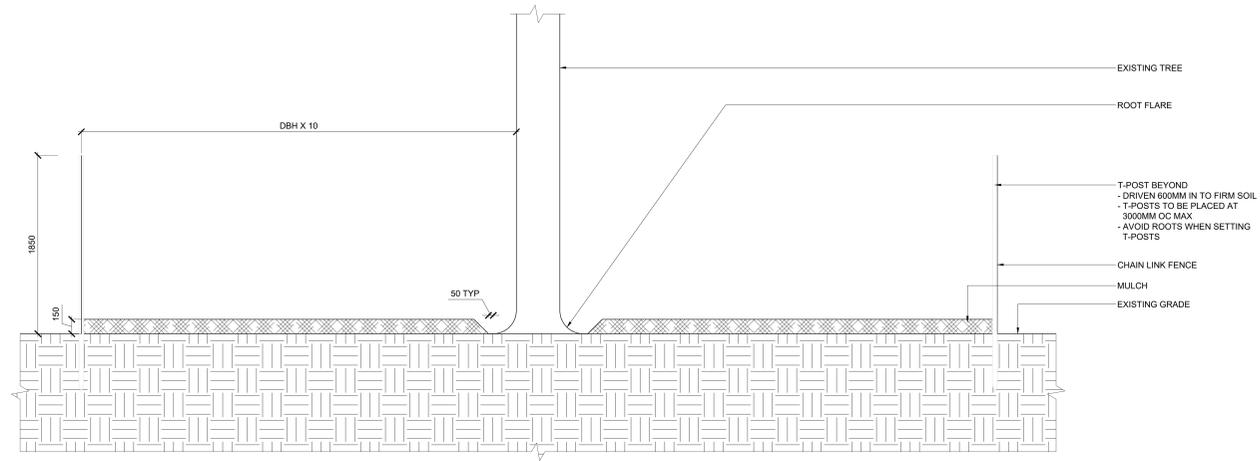

- NOTES:
- IF WORK IS REQUIRED WITHIN THE TREE PROTECTION FENCE, CONTRACTOR TO NOTIFY LANDSCAPE ARCHITECT. WORK MUST BE DONE UNDER SUPERVISION OF PROJECT ARBORIST.
 - IF EQUIPMENT IS REQUIRED TO TRAVERSE TREE PROTECTION ZONE, CONTRACTOR TO INSTALL 25mm PLYWOOD OVER THE 150mm MULCH LAYER. SECURE PLYWOOD PIECES WITH CLAMPS. FENCE EXTENTS ARE TYPICAL UNLESS OTHERWISE INDICATED IN PLANS.
 - IF EQUIPMENT IS REQUIRED TO TRAVERSE TREE PROTECTION ZONE, CONTRACTOR TO INSTALL 25mm PLYWOOD OVER THE 150mm MULCH LAYER. SECURE PLYWOOD PIECES WITH CLAMPS. FENCE EXTENTS ARE TYPICAL UNLESS OTHERWISE INDICATED IN PLANS.

2 TREE PROTECTION FENCE
SCALE 1: 20 0 100 500 1000mm SECTION

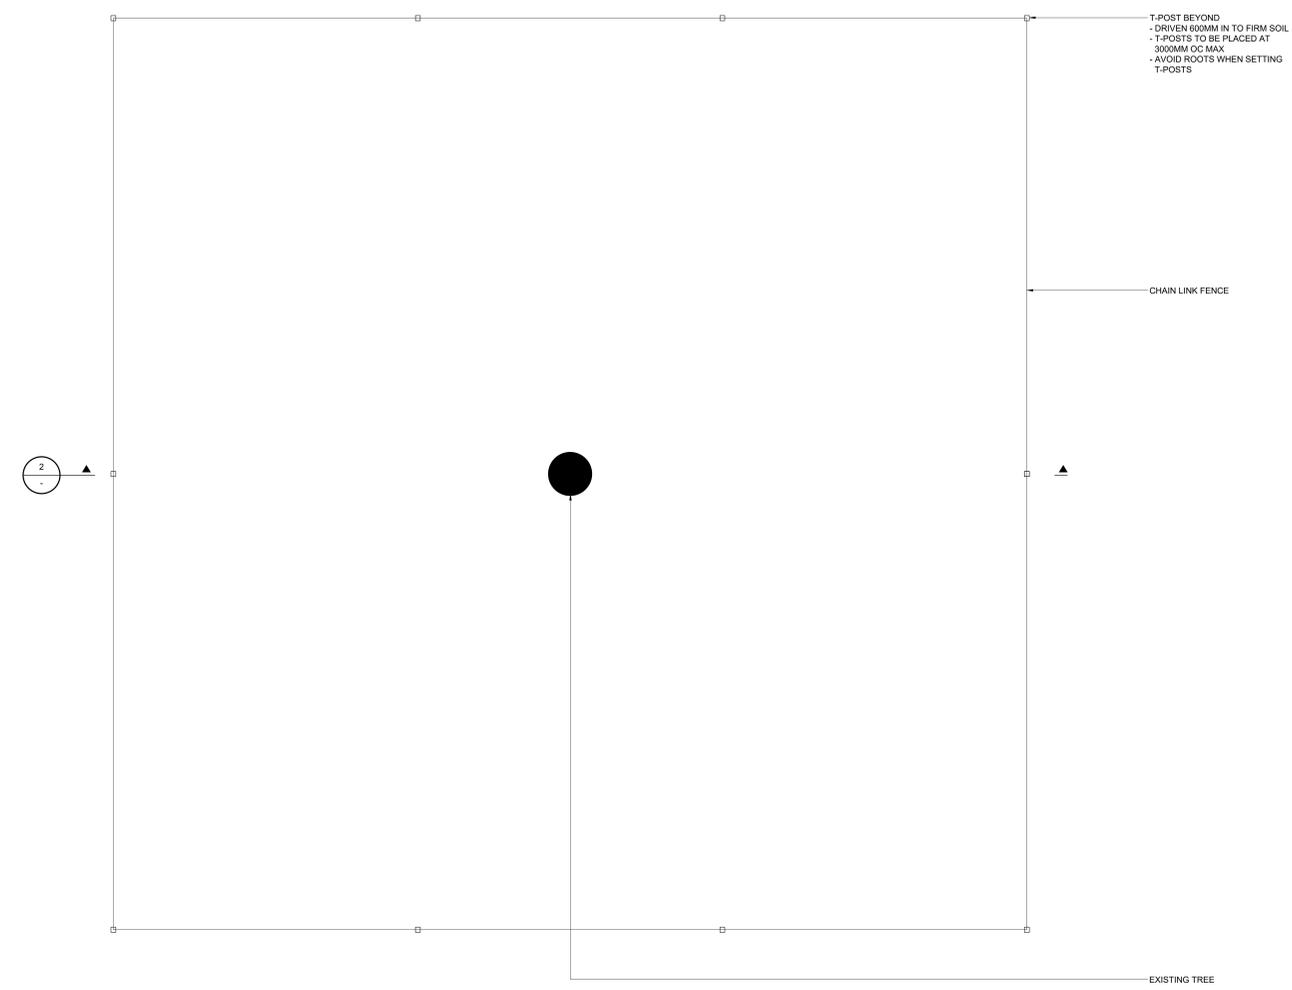

1 TREE PROTECTION FENCE
SCALE 1: 20 0 100 500 1000mm PLAN

PROJECT
THE OTTAWA HOSPITAL
NEW CAMPUS
DEVELOPMENT -
PHASE 4 MAIN HOSPITAL
BUILDING
900 CARLING AVE, OTTAWA, ONTARIO

CLIENT
The Ottawa Hospital | L'Hôpital d'Ottawa

Infrastructure Ontario

PCL CONSTRUCTION | **EllisDon**

CLIENT PROJECT NO. 1070002

KEY PLAN

THIS DRAWING TO BE PRINTED IN COLOUR

NO.	REVISIONS	DATE
04	SITE PLAN CONTROL, RESUBMISSION	2025-01-13
03	85% DD SUBMISSION	2025-09-19
02	SITE PLAN CONTROL, RESUBMISSION	2025-06-09
01	65% DD SUBMISSION	2025-09-09
00	ISSUED	DATE

DRAWING STATUS
NOT FOR CONSTRUCTION

DISCREPANCIES MUST BE REPORTED IMMEDIATELY TO THE ARCHITECT BEFORE PROCEEDING.
ONLY FIGURED DIMENSIONS ARE TO BE USED. CONTRACTORS MUST CHECK ALL DIMENSIONS ON SITE. THIS DRAWING IS PROTECTED BY COPYRIGHT.
ALL DIMENSIONS ARE SHOWN IN METRIC.

AUTHOR
PWP

PROJECT TEAM
DESIGN/BUILDER PCL ED A JOINT VENTURE
ARCHITECTURAL PARSON ARCHITECTS LIMITED, ZOOCH LABARRE PRATTE ARCHITECTS, ADAMSON ASSOCIATE ARCHITECTS, 888 ARCHITECTS INC.
STRUCTURAL STEPHENSON ENGINEERING LTD, BOUTHILLET PARIZEAU INC.
MECHANICAL HI ANGLIS & ASSOCIATES LTD, CROSSEY ENGINEERING LTD.
ELECTRICAL KELVEY & BIRN INTERNATIONAL INC.
CIVIL HEP CANADA INC.
LANDSCAPE VERTECOBS DESIGN INC, PWP LANDSCAPE ARCHITECTURE
BUILDING CODE UMCG BUILDING CODE CONSULTANTS LTD.

AUTHOR PROJECT NO. PCL2301_C

STAMP

DRAWING TITLE
PLANTING DETAILS

DRAWN	CHECKED
-	-

SCALE AT 42" x 60" DATE 05-JUN-2025
AS NOTED
GRAPHIC SCALE AS NOTED

DRAWING NO. L27-101 **REV NO.** 04