



1875 (1/4" = 1'-0") CUSTOM SHEET SIZE

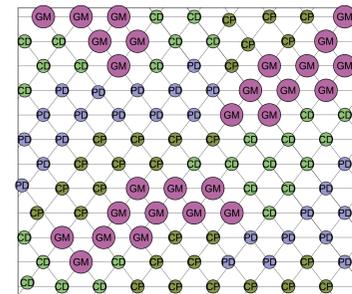


MIX 1

PLANT MIX 1			
CD	CAREX DIVULSA	25%	1 GALLON 12"
CP	CAREX PENNSYLVANICA	26%	1 GALLON 12"
GM	GERANIUM MACULATUM	25%	3 GALLON 12"
PD	PHLOX DIVARICATA	24%	1 GALLON 12"

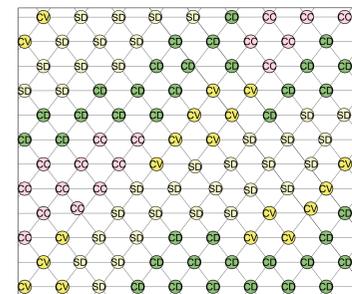


MIX 2

PLANT MIX 2			
SD	CAREX DIVULSA	34%	1 GALLON 12"
CC	CORNUS CANADENSIS	16%	1 GALLON 12"
CV	CHRYSOGONUM VIRGINIANUM	18%	1 GALLON 12"
ST	STYLOPHORUM DIPHYLLUM	32%	1 GALLON 12"

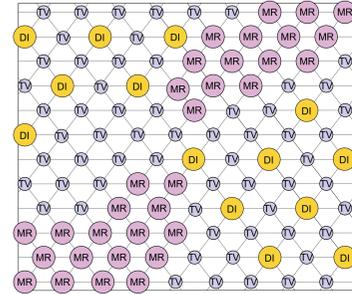


MIX 3

PLANT MIX 3			
MR	MAIANTHEMUM RACEMOSUM	30%	3 GALLON 12"
DI	DIERVILLA IONICERA	13%	3 GALLON 24"
TV	TRADESCANTIA VIRGINIANA	57%	1 GALLON 12"

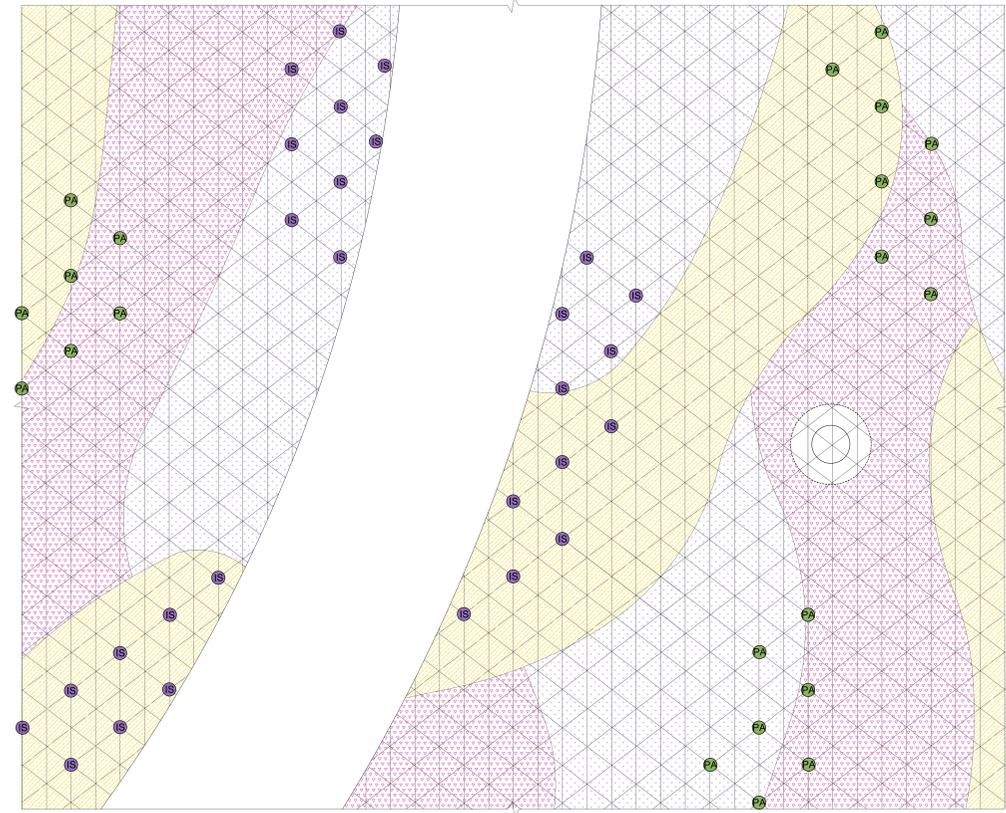

PEDESTRIAN PATH
PROPOSED TREE, TYP.
1 ZONE 2 WOODLAND EDGE MIX
SCALE: 1/2" = 1'
0 1 2 3 4 5 PLANTING ENLARGEMENT

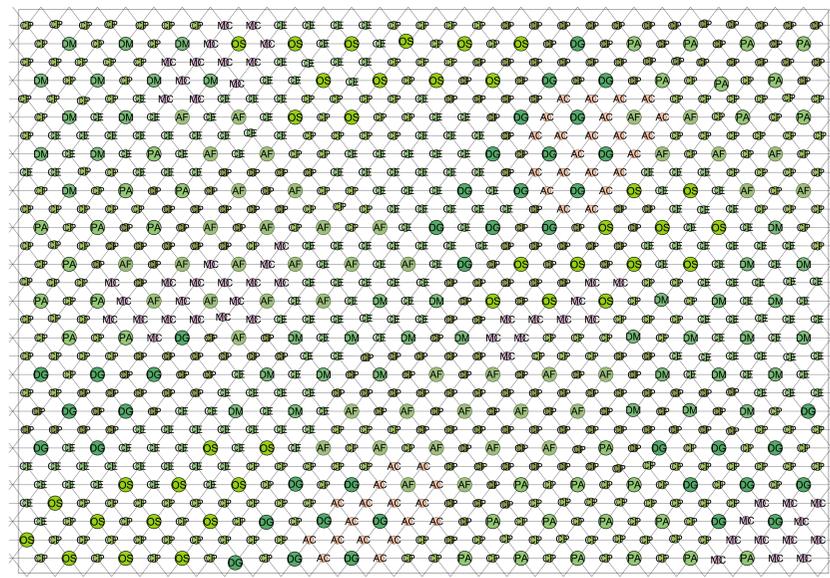

1 ZONE 1 SHADY WOODLAND TYPICAL LAYOUT
SCALE: 1/2" = 1'
0 1 2 3 4 5 PLANTING ENLARGEMENT

2 ZONE 2 WOODLAND EDGE MIX - 12" O.C

CD	CAREX DIVULSA	1 GALLON 12"
CP	CAREX PENNSYLVANICA	1 GALLON 12"
CC	CORNUS CANADENSIS	1 GALLON 12"
CV	CHRYSOGONUM VIRGINIANUM	1 GALLON 12"
DI	DIERVILLA IONICERA	3 GALLON 24"
GM	GERANIUM MACULATUM	3 GALLON 12"
IS	IRIS SIBIRICA	BULBS 24"
MR	MAIANTHEMUM RACEMOSUM	3 GALLON 12"
PD	PHLOX DIVARICATA	1 GALLON 12"
PA	PTERIDIUM AQUILINUM	1 GALLON 24"
SD	STYLOPHORUM DIPHYLLUM	1 GALLON 12"
TV	TRADESCANTIA VIRGINIANA	1 GALLON 12"

MIX 1

CD	CAREX DIVULSA
CP	CAREX PENNSYLVANICA
GM	GERANIUM MACULATUM
PD	PHLOX DIVARICATA

MIX 2

SD	CAREX DIVULSA
CC	CORNUS CANADENSIS
CV	CHRYSOGONUM VIRGINIANUM
SD	STYLOPHORUM DIPHYLLUM

MIX 3

MR	MAIANTHEMUM RACEMOSUM
DI	DIERVILLA IONICERA
TV	TRADESCANTIA VIRGINIANA

INDIVIDUAL SPECIES

IS	IRIS SIBIRICA
PA	PTERIDIUM AQUILINUM

1 ZONE 1 SHADY WOODLAND MIX - 9" O.C

AC	ASARUM CANADENSE	5%	PLUG 9"
AF	ATHYRIUM FILIX-FEMINA	5%	1 GALLON 18"
GE	CAREX EBURNEA	21%	PLUG 9"
CP	CAREX PENNSYLVANICA	21%	PLUG 9"
CP	CAREX PLATYPHYLLA	25%	PLUG 9"
DR	DRYOPTERIS GOLDIANA	5%	1 GALLON 18"
MC	DRYOPTERIS MARGINALIS	5%	1 GALLON 18"
MC	MAIANTHEMUM CANADENSE	5%	PLUG 9"
ON	ONOCLEA SENSIBILIS	4%	1 GALLON 18"
PA	POLYSTICHUM ACROSTICHOIDES	4%	1 GALLON 18"

PROJECT
**THE OTTAWA HOSPITAL
NEW CAMPUS
DEVELOPMENT -
PHASE 4 MAIN HOSPITAL
BUILDING**
900 CARLING AVE. OTTAWA ONTARIO

CLIENT
The Ottawa Hospital | L'Hôpital d'Ottawa

Infrastructure Ontario

PCL CONSTRUCTION | EllisDon

CLIENT PROJECT NO. **1070002**

KEY PLAN

THIS DRAWING TO BE PRINTED IN COLOUR

NO.	DESCRIPTION	DATE
02	SITE PLAN CONTROL, RESUBMISSION	2020-01-10
01	95% DD SUBMISSION	2020-09-10
00	ISSUED	DATE

REVISIONS

DRAWING STATUS

NOT FOR CONSTRUCTION

COORDINANCES MUST BE REPORTED IMMEDIATELY TO THE ARCHITECT BEFORE PROCEEDING. ONLY FIGURED DIMENSIONS ARE TO BE USED. CONTRACTORS MUST CHECK ALL DIMENSIONS ON SITE. THIS DRAWING IS PROTECTED BY COPYRIGHT.

ALL DIMENSIONS ARE SHOWN IN METRIC.

AUTHOR

PWP

PROJECT TEAM

DESIGN/BUILDER: POLED, A JOINT VENTURE
PARRON ARCHITECTS LIMITED
JOSHUA MARINE PRATTE ARCHITECTS
ADAMSON ASSOCIATE ARCHITECTS
888 WINDING INC.

STRUCTURAL: STEPHENSON ENGINEERING LTD.
BOUHLLETTE PARBEAU INC.

MECHANICAL: HJ ANGLIS & ASSOCIATES LTD.
CROSSEY ENGINEERING LTD.

ELECTRICAL: MCELVEY & BIRNAN INTERNATIONAL INC.
HEP CANADA INC.

CIVIL: VERTICUS DESIGN INC.

LANDSCAPE: PWP LANDSCAPE ARCHITECTURE

BUILDING CODE: UMCG BUILDING CODE CONSULTANTS LTD.

AUTHOR PROJECT NO. **PCL2301_C**

STAMP

DRAWING TITLE
PLANTING ENLARGEMENTS

DRAWN	CHECKED

SCALE AT 40" x 60"
AS NOTED

DATE
19-SEPT-2025

GRAPHIC SCALE
AS NOTED

DRAWING NO. **L27-110** REV NO. **02**