


100% COPY - NOT FOR CONSTRUCTION

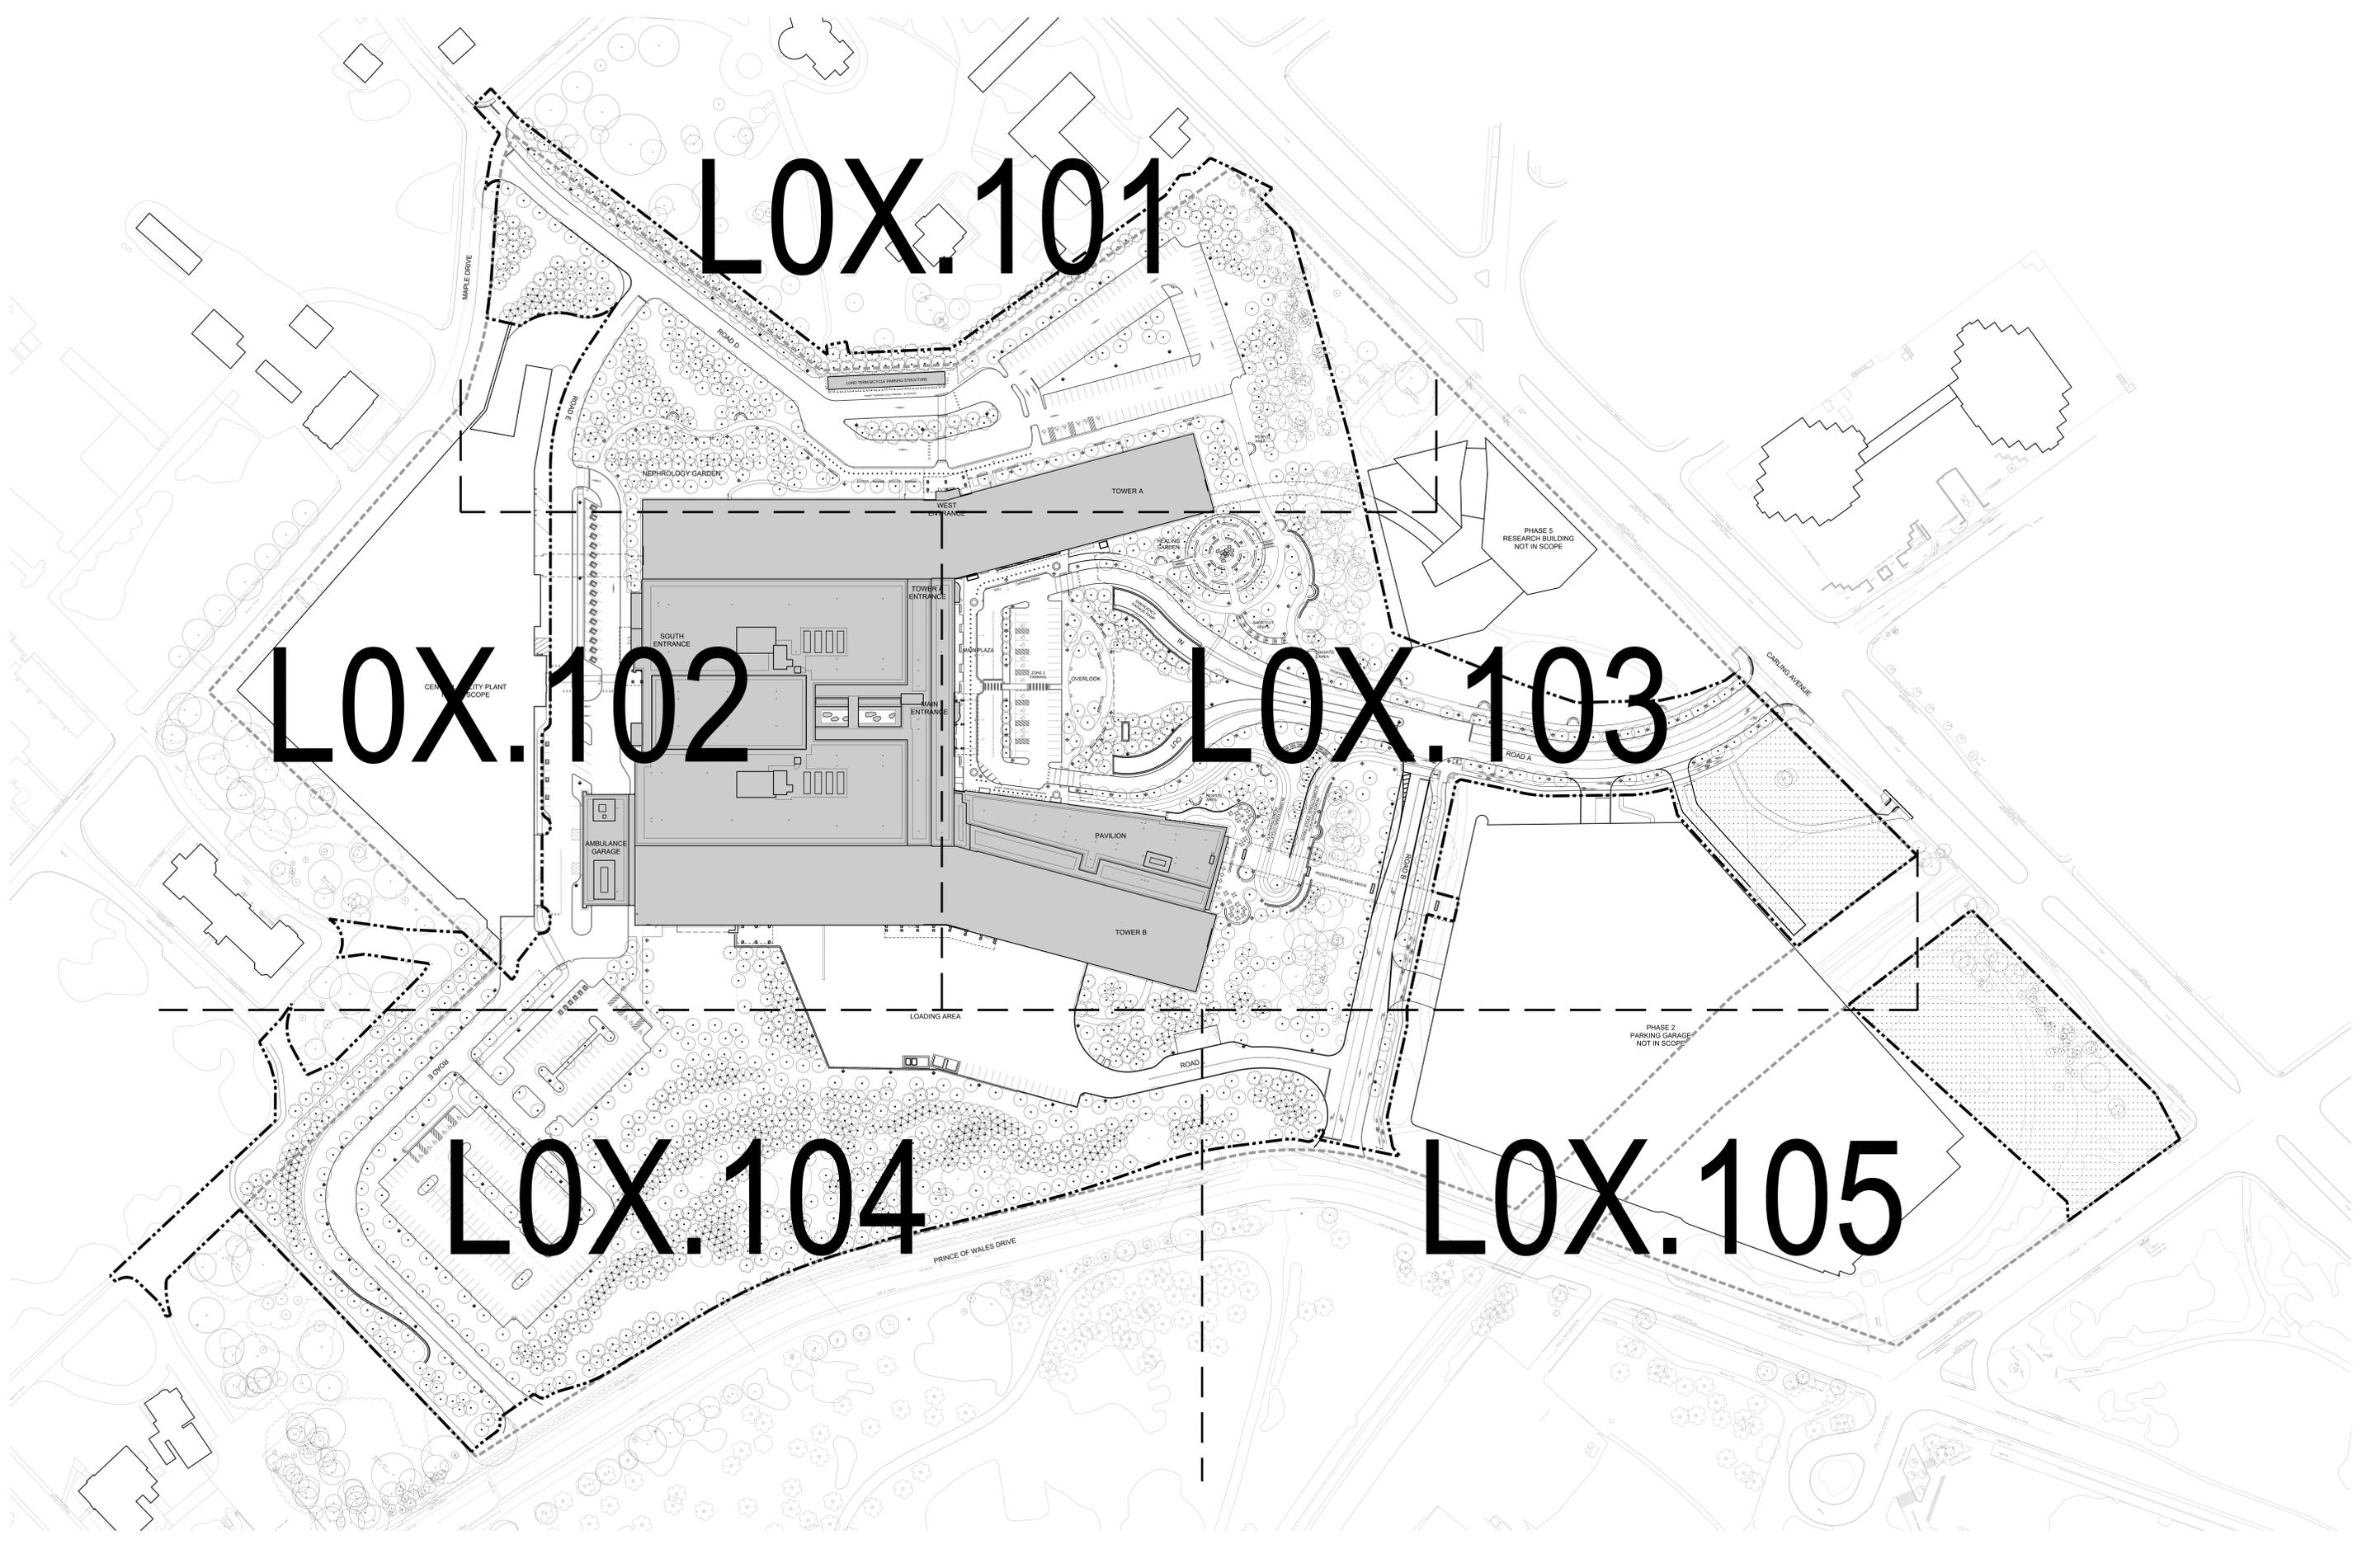

LOX.101

LOX.102

LOX.103

LOX.104

LOX.105

PROJECT
THE OTTAWA HOSPITAL
NEW CAMPUS
DEVELOPMENT -
PHASE 4 MAIN HOSPITAL
BUILDING
900 CARLING AVE. OTTAWA ONTARIO

CLIENT
The Ottawa Hospital | L'Hôpital d'Ottawa

Infrastructure Ontario

PCL CONSTRUCTION | **EllisDon**

CLIENT PROJECT NO. 1070002

KEY PLAN
TRUE NORTH | PROJECT NORTH

THIS DRAWING TO BE PRINTED IN COLOUR.

NO.	DESCRIPTION	DATE
07	SITE PLAN CONTROL, RESUBMISSION	2026-01-10
06	90% DD SUBMISSION	2025-06-19
05	SITE PLAN CONTROL, RESUBMISSION	2025-04-05
04	65% DD SUBMISSION	2025-06-05
03	35% DD SUBMISSION	2025-01-28
02	ACFOR READINESS	2025-01-09
01	80% SD SUBMISSION	2024-08-15
00	ISSUED	DATE

REVISIONS

NOT FOR CONSTRUCTION
COORDINATES MUST BE REPORTED IMMEDIATELY TO THE ARCHITECT BEFORE PROCEEDING. ONLY FIGURED DIMENSIONS ARE TO BE USED. CONTRACTORS MUST CHECK ALL DIMENSIONS ON SITE. THIS DRAWING IS PROTECTED BY COPYRIGHT.
ALL DIMENSIONS ARE SHOWN IN METRIC.

AUTHOR
PWP

PROJECT TEAM
DESIGN/BUILDER: POLED, A JOINT VENTURE
ARCHITECTURAL: PARSON ARCHITECTS LIMITED, JOONIL LAMARIE PRATTE ARCHITECTS, ADAMSON ASSOCIATE ARCHITECTS, 888 ARCHITECTS INC.
STRUCTURAL: STEPHENSON ENGINEERING LTD., SOUTHLEITE PARIZEAU INC.
MECHANICAL: H.H. ANGLIS & ASSOCIATES LTD., CROSBY ENGINEERING LTD.
ELECTRICAL: MELVEY & SWANN INTERNATIONAL INC.
CIVIL: HEP O'NEILL INC.
LANDSCAPE: VERTECOBS DESIGN INC., PWP LANDSCAPE ARCHITECTURE

BUILDING CODE UMOG BUILDING CODE CONSULTANTS LTD.
AUTHOR PROJECT NO. PCL2301_C

DRAWING NO. L00-013 | **REV NO.** 07

DRAWING TITLE SHEET TILING PLAN

DRAWN | **CHECKED**
SCALE AT 40" x 60" | DATE 15-AUG-2024
GRAPHIC SCALE | SCALE IN METERS