
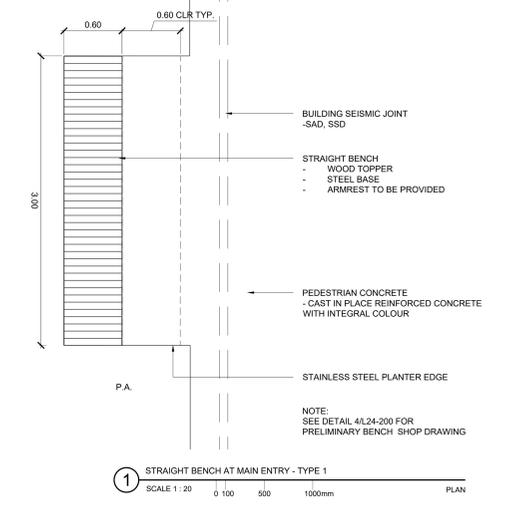
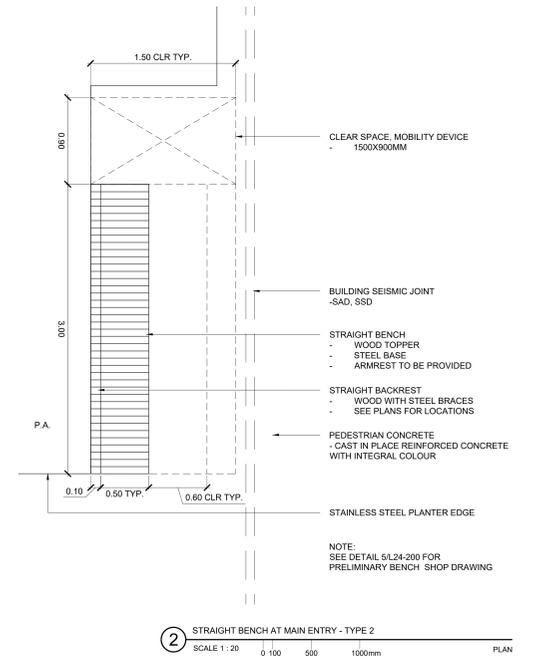
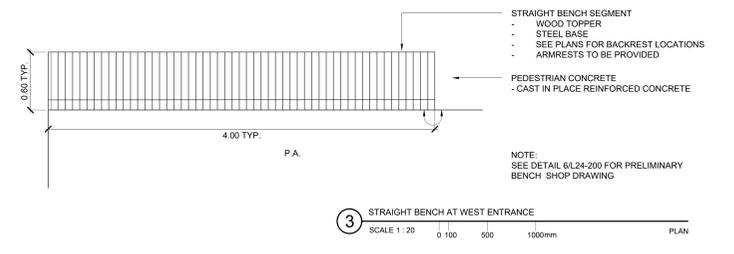
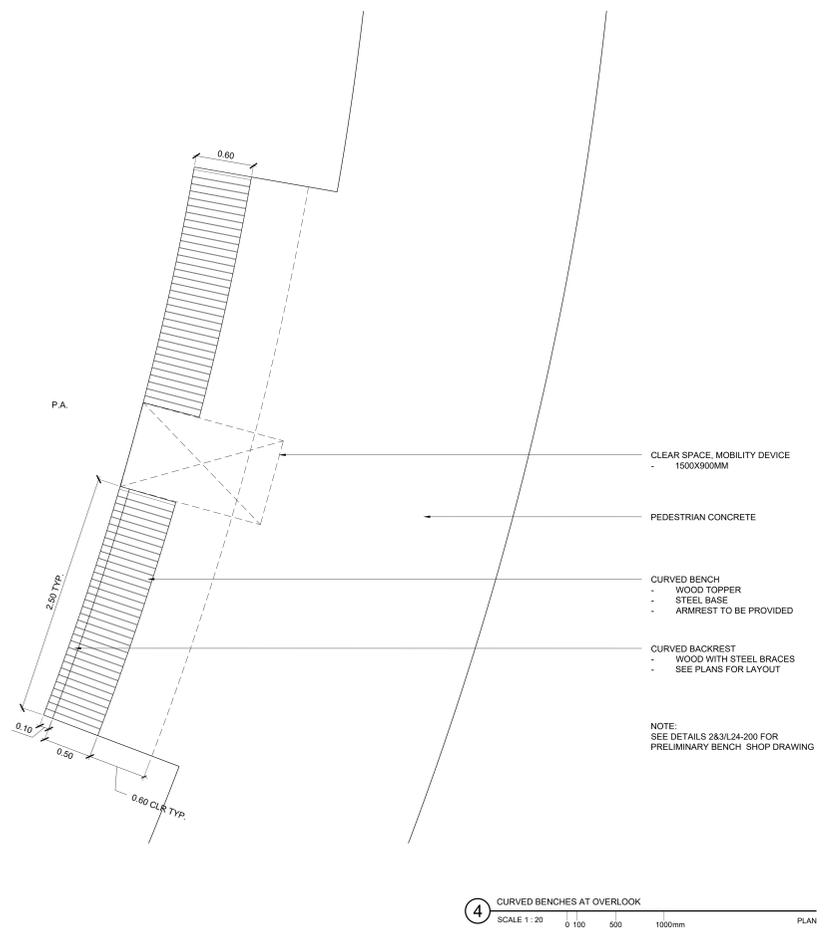
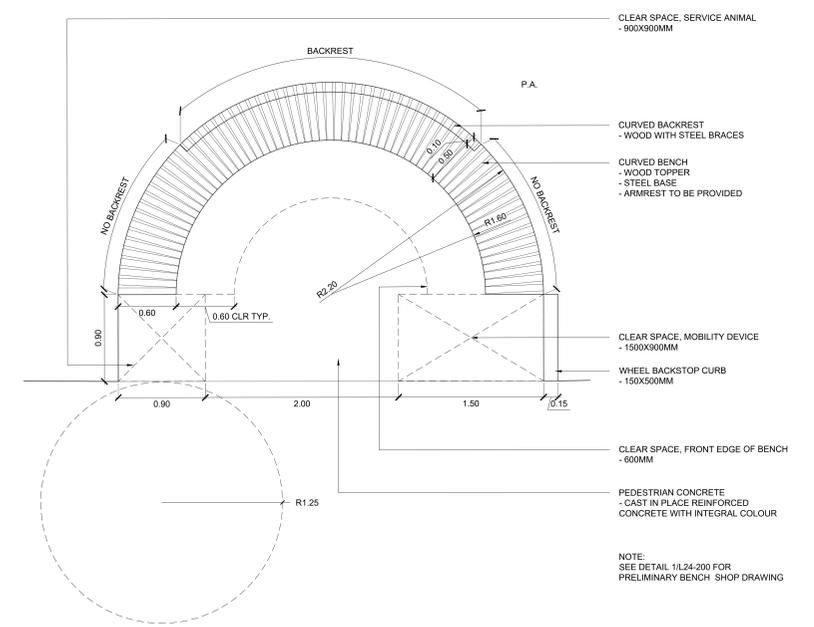
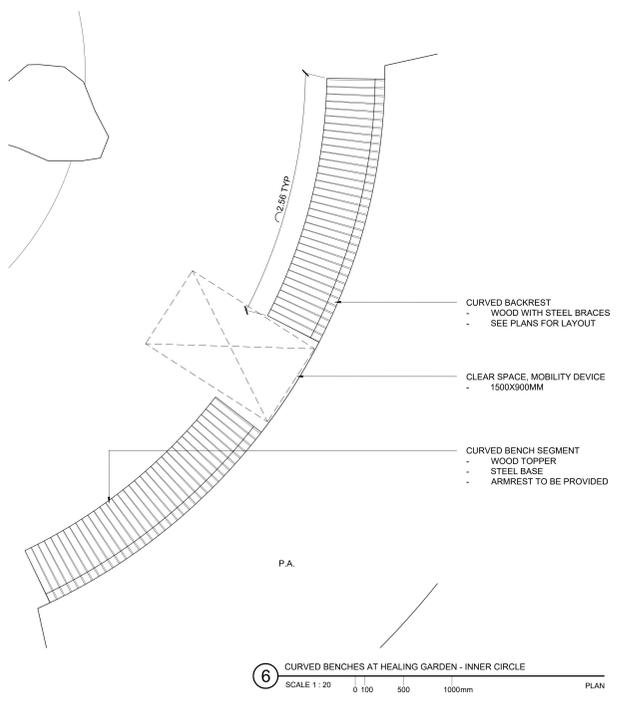
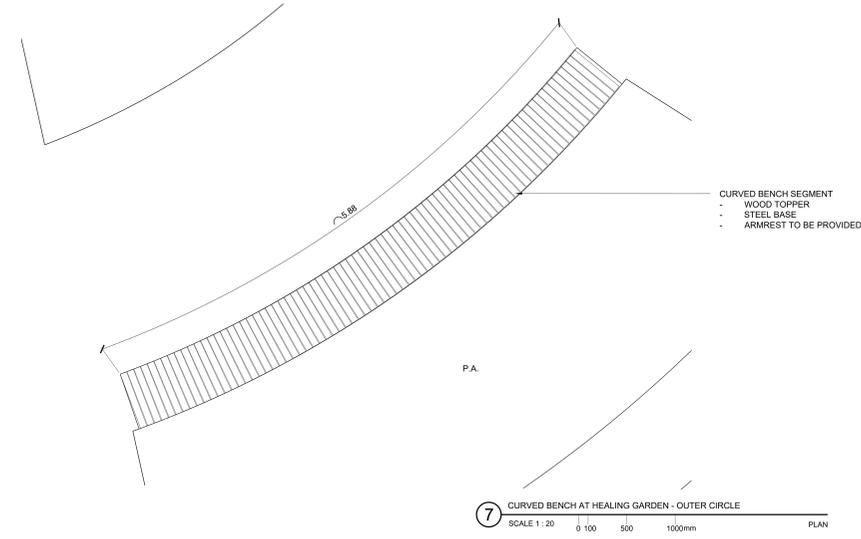


THIS DRAWING IS THE PROPERTY OF PWP AND IS NOT TO BE REPRODUCED OR TRANSMITTED IN ANY FORM OR BY ANY MEANS, ELECTRONIC OR MECHANICAL, WITHOUT THE WRITTEN PERMISSION OF PWP.

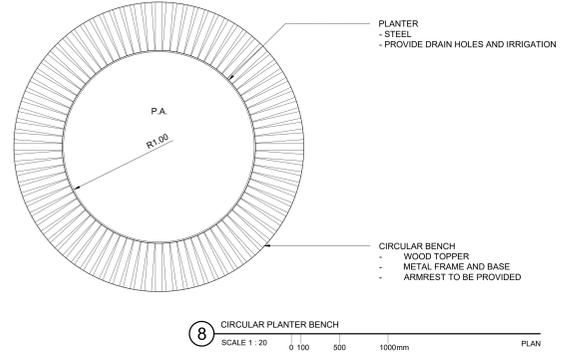

PROJECT
THE OTTAWA HOSPITAL
NEW CAMPUS
DEVELOPMENT -
PHASE 4 MAIN HOSPITAL
BUILDING
900 CARLING AVE. OTTAWA ONTARIO

CLIENT
The Ottawa Hospital | L'Hôpital d'Ottawa

Infrastructure Ontario

PCL CONSTRUCTION | **EllisDon**

CLIENT PROJECT NO. 1070002

KEY PLAN
TRUE NORTH | PROJECT NORTH

THIS DRAWING TO BE PRINTED IN COLOUR

NO.	REVISIONS	DATE
04	SITE PLAN CONTROL, RESUBMISSION	2025-01-13
03	85% DD SUBMISSION	2025-09-19
02	SITE PLAN CONTROL, RESUBMISSION	2025-06-05
01	65% DD SUBMISSION	2025-09-05
00	ISSUED	DATE

REVISIONS

DRAWING STATUS

NOT FOR CONSTRUCTION
DISCREPANCIES MUST BE REPORTED IMMEDIATELY TO THE ARCHITECT BY PHONE OR PROCEEDING. ONLY FIGURED DIMENSIONS ARE TO BE USED. CONTRACTORS MUST CHECK ALL DIMENSIONS ON SITE. THIS DRAWING IS PROTECTED BY COPYRIGHT.

AUTHOR
PWP

PROJECT TEAM
DESIGN BUILDER POLIED A JOINT VENTURE
ARCHITECTURAL PARSON ARCHITECTS LIMITED, ZOOHL LAMARIE PRATTE ARCHITECTS, ADAMSON ASSOCIATE ARCHITECTS, 888 ARCHITECTS INC.
STRUCTURAL STEPHENSON ENGINEERING LTD, BOUTHILLET PARIZEAU INC.
MECHANICAL HI ANGLIS & ASSOCIATES LTD, CROSBY ENGINEERING LTD.
ELECTRICAL MELVEY & BIRN INTERNATIONAL INC.
CIVIL WSP | PARSONS INC.
LANDSCAPE VERTECOBS DESIGN INC, PWP LANDSCAPE ARCHITECTURE
BUILDING CODE UMUG BUILDING CODE CONSULTANTS LTD.

AUTHOR PROJECT NO. PCL2301_C

STAMP

DRAWING TITLE
SITE FURNISHING DETAILS

DRAWN	CHECKED
SCALE AT 42" x 60"	DATE
AS NOTED	05-JUN-2025

GRAPHIC SCALE AS NOTED

DRAWING NO. L24-101 | **REV NO.** 04