


DATE PLOTTED: 15-AUG-2024 10:00:00 AM

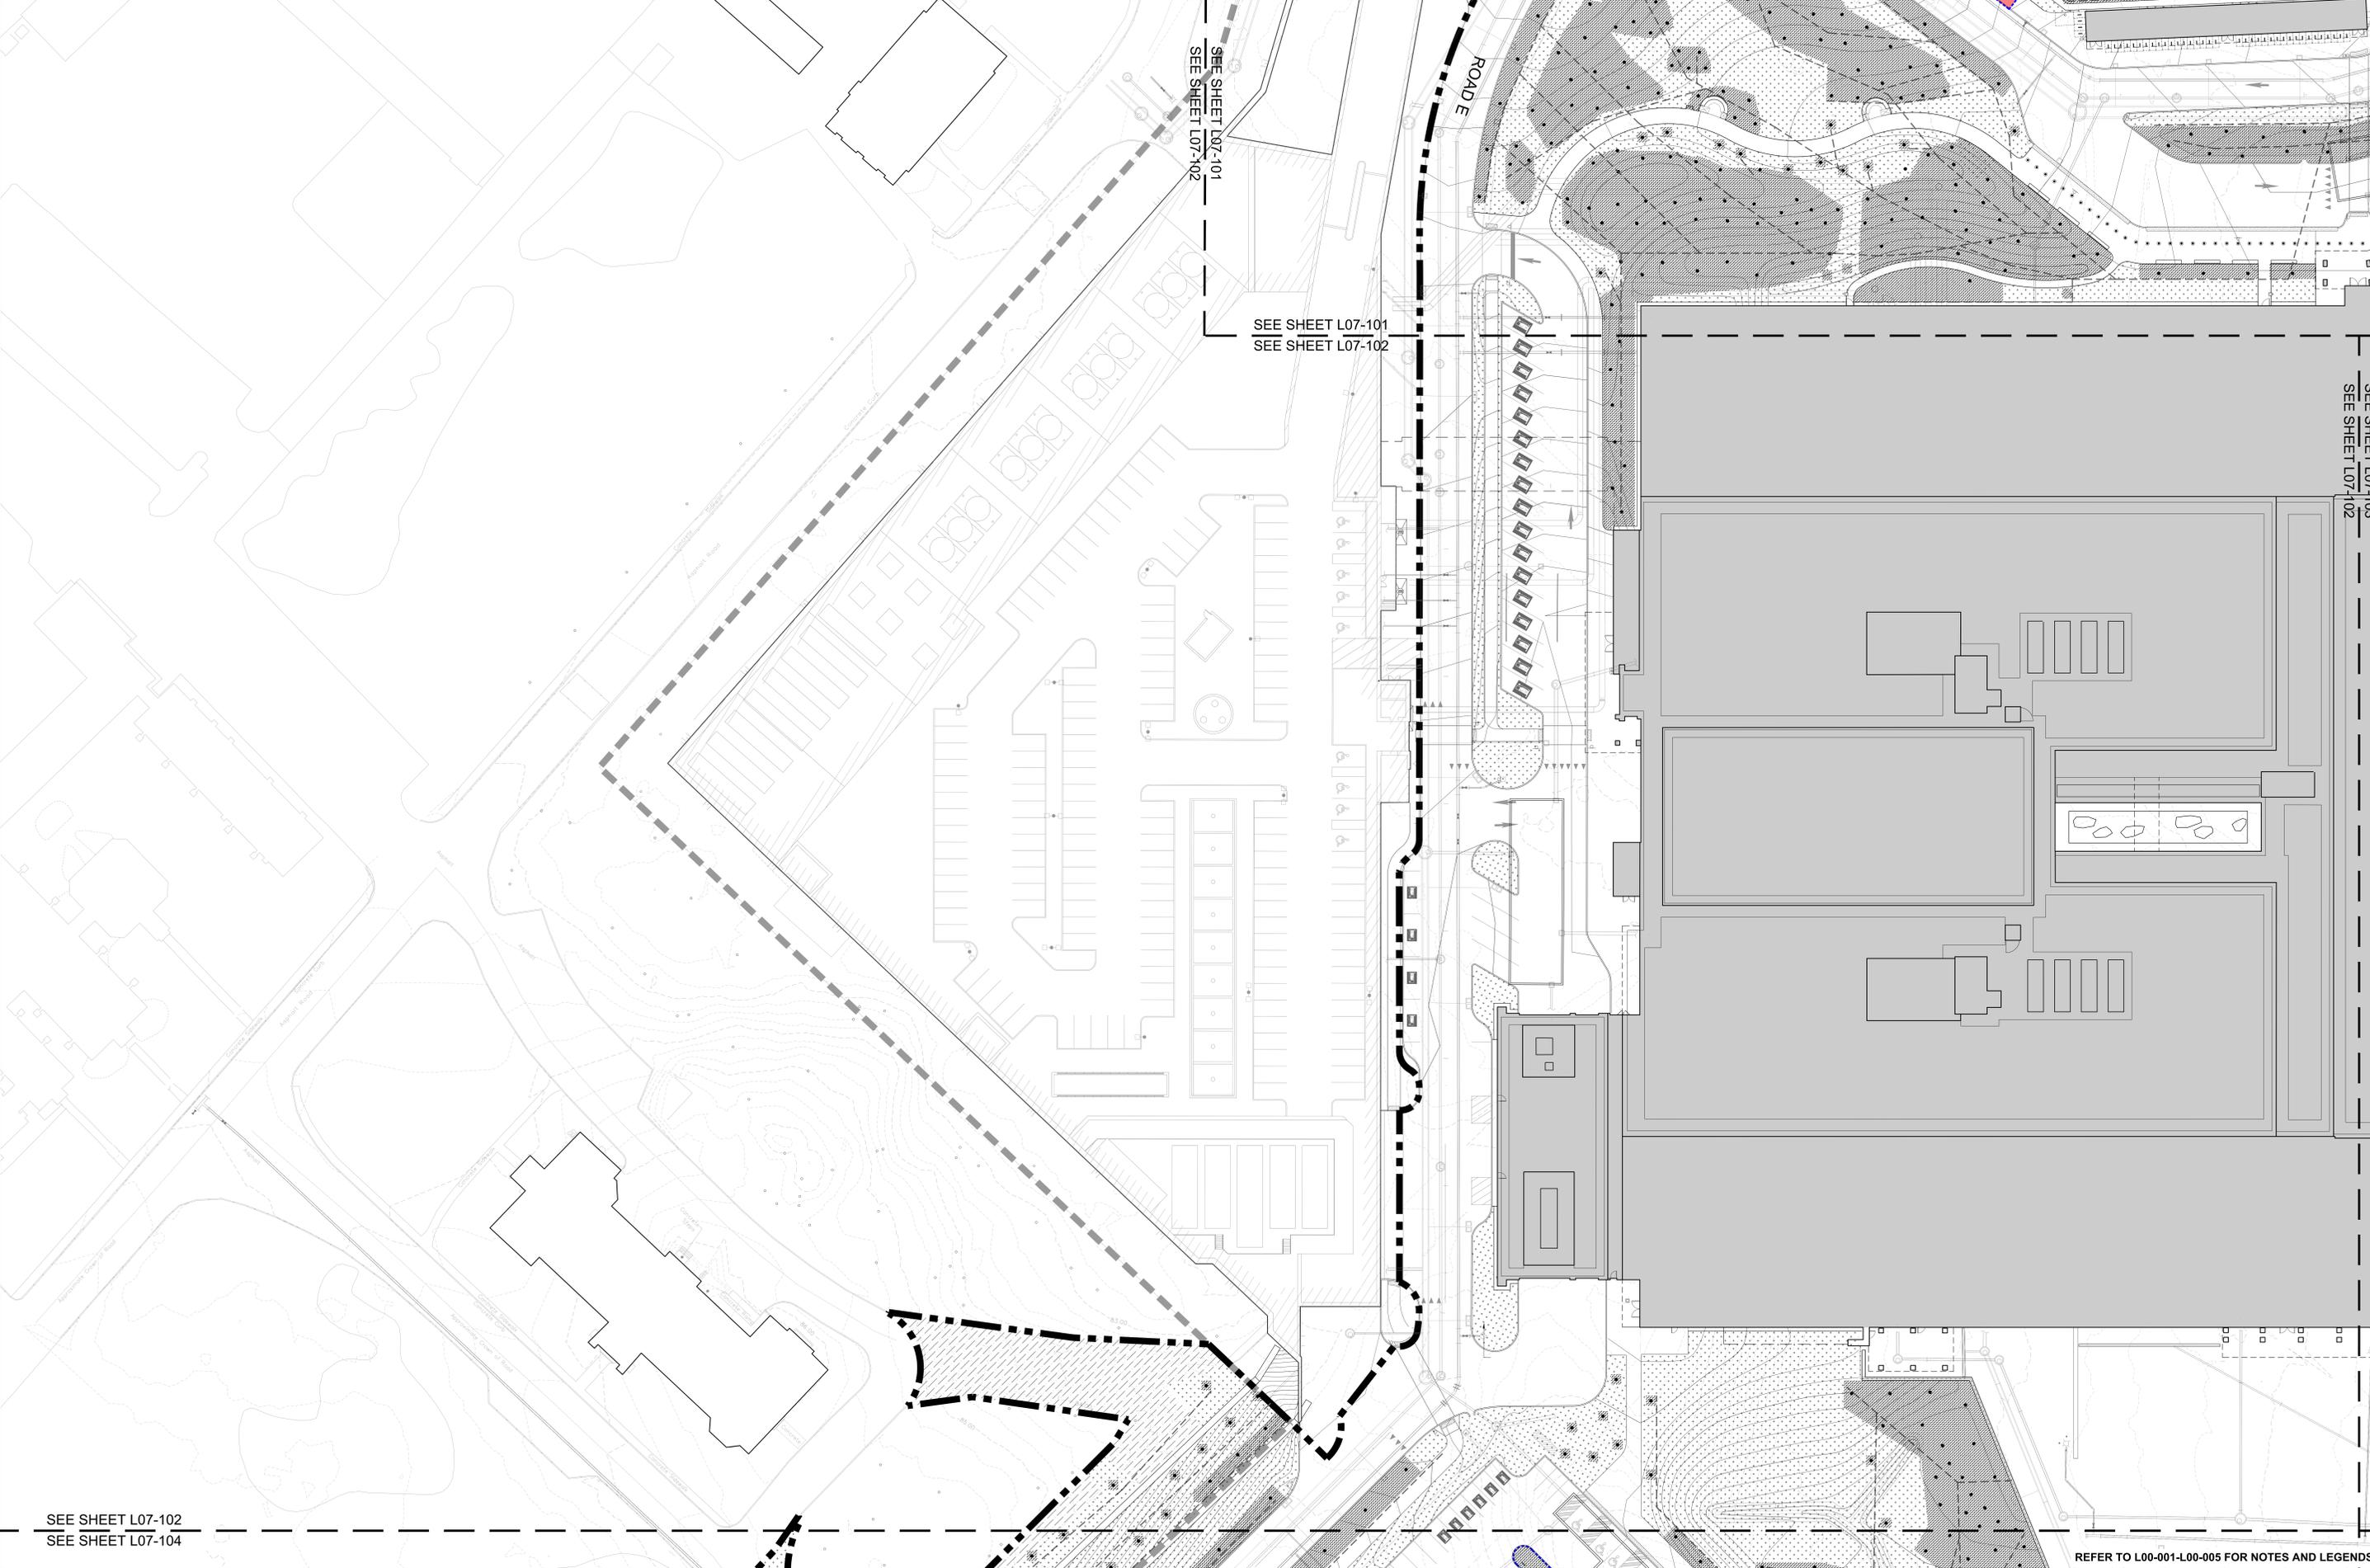

**PROJECT**  
THE OTTAWA HOSPITAL  
NEW CAMPUS  
DEVELOPMENT -  
PHASE 4 MAIN HOSPITAL  
BUILDING  
900 CARLING AVE. OTTAWA, ONTARIO

**CLIENT**  
The Ottawa Hospital | L'Hôpital d'Ottawa

**INFRASTRUCTURE ONTARIO**

**PCL CONSTRUCTION** | **EllisDon**

**CLIENT PROJECT NO.** 1070002

**KEY PLAN**  
TRUE NORTH | PROJECT NORTH

**THIS DRAWING TO BE PRINTED IN COLOUR.**

NO.	DESCRIPTION	DATE
07	SITE PLAN CONTROL RESUBMISSION	2026-01-12
06	90% DD SUBMISSION	2025-06-19
05	SITE PLAN CONTROL RESUBMISSION	2025-04-08
04	65% DD SUBMISSION	2025-06-26
03	35% DD SUBMISSION	2025-07-28
02	ACFOR READINESS	2025-01-09
01	80% DD SUBMISSION	2024-08-15
00	ISSUED	DATE

**REVISIONS**

**DRAWING STATUS**  
**NOT FOR CONSTRUCTION**

DISCREPANCIES MUST BE REPORTED IMMEDIATELY TO THE ARCHITECT BEFORE PROCEEDING.  
ONLY FIGURED DIMENSIONS ARE TO BE USED. CONTRACTORS MUST CHECK ALL DIMENSIONS ON SITE. THIS DRAWING IS PROTECTED BY COPYRIGHT.  
ALL DIMENSIONS ARE SHOWN IN METRIC.

**AUTHOR**  
PWP

**PROJECT TEAM**  
DESIGN/BUILDER: PCL, A JOINT VENTURE  
ARCHITECTURAL: PARON ARCHITECTS LIMITED, ZOOH LABARNE PRATTE ARCHITECTS, ADAMSON ASSOCIATE ARCHITECTS, 888 WICHOWSKI INC.  
STRUCTURAL: STEPHENSON ENGINEERING LTD., BOUTHILLETTE PARIZEAU INC.  
MECHANICAL: HFI ANGUS & ASSOCIATES LTD., CROSBY ENGINEERING LTD.  
ELECTRICAL: MELVEY & SWANN INTERNATIONAL INC., HEP SWANN INC.  
CIVIL: HEP SWANN INC.  
LANDSCAPE: VERTECORS DESIGN INC., PWP LANDSCAPE ARCHITECTURE  
BUILDING CODE: UMG BUILDING CODE CONSULTANTS LTD.

**AUTHOR PROJECT NO.** PCL2301\_C

STAMP	STAMP

**DRAWING TITLE**  
SOILS PLAN

DRAWN	CHECKED

SCALE AT 40' x 60' | DATE 15-AUG-2024  
GRAPHIC SCALE | SCALE IN METERS

**DRAWING NO.** L07-102 | **REV NO.** 07

REFER TO L00-001-L00-005 FOR NOTES AND LEGENDS

SEE SHEET L07-102  
SEE SHEET L07-104

SEE SHEET L07-103  
SEE SHEET L07-102

SEE SHEET L07-101  
SEE SHEET L07-102

SEE SHEET L07-101  
SEE SHEET L07-102

L07-102 07