


DATE PLOTTED: 15-AUG-2024 10:58:15 AM

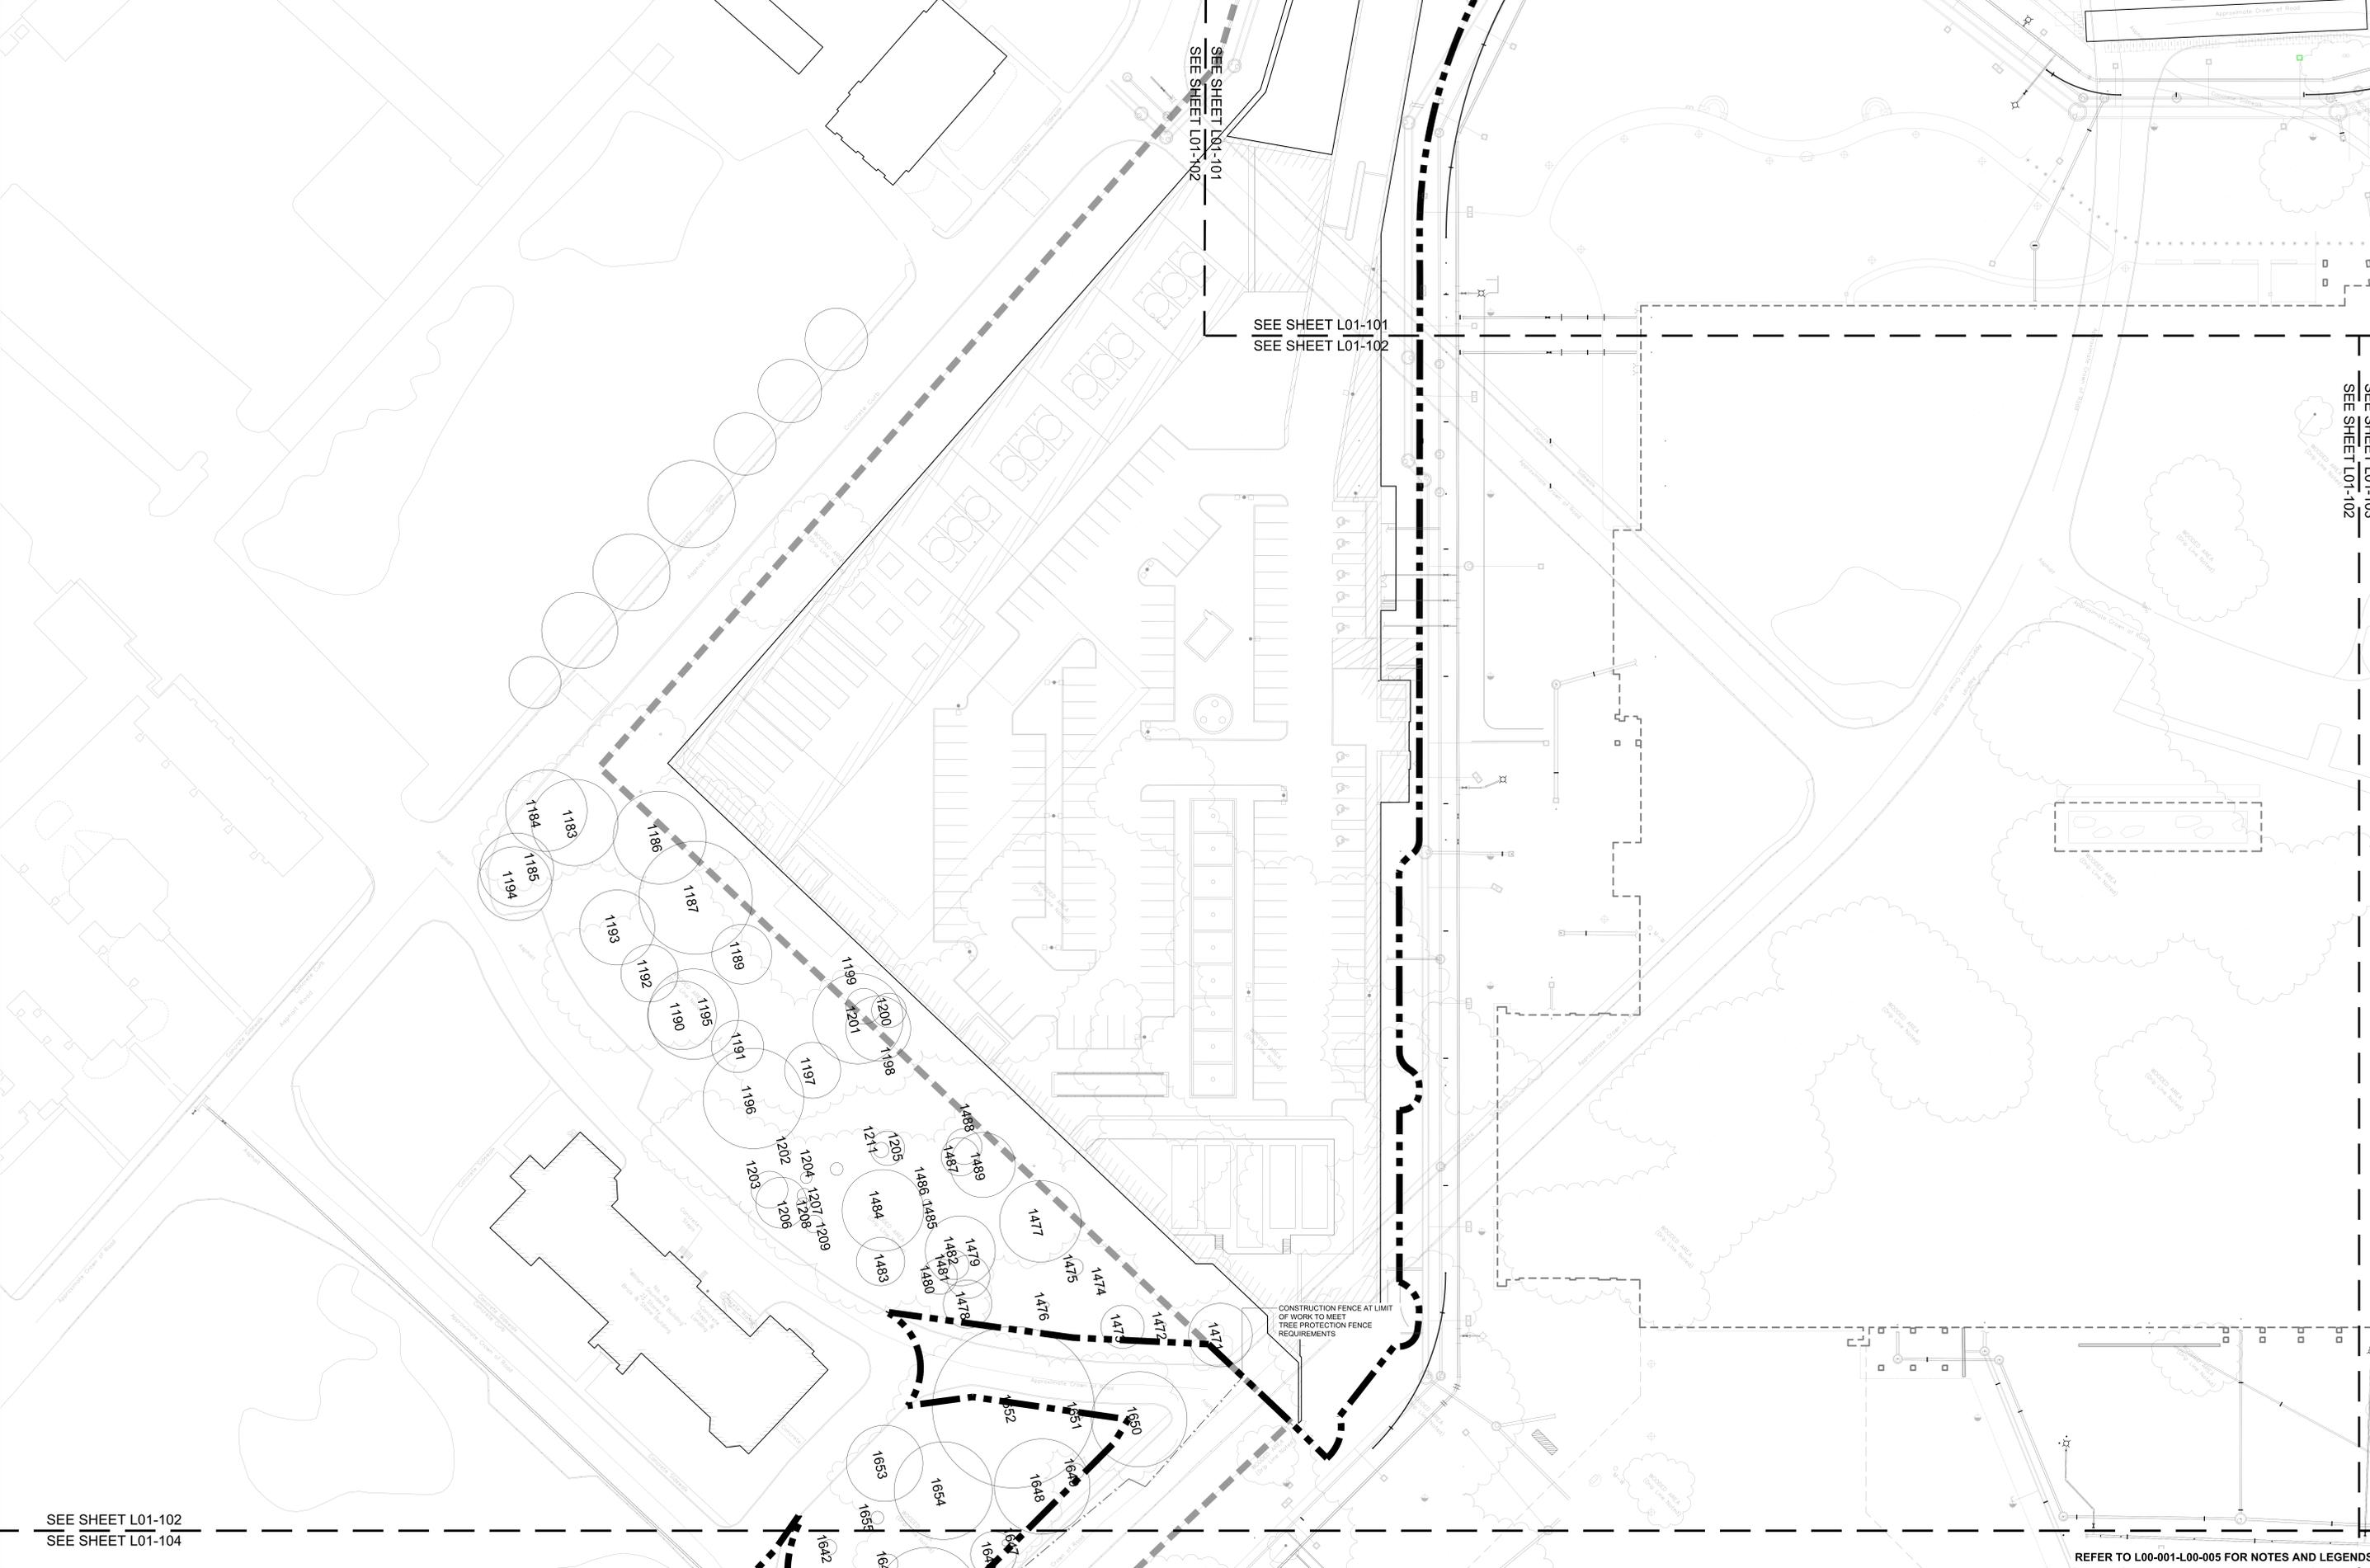

PROJECT
THE OTTAWA HOSPITAL
NEW CAMPUS
DEVELOPMENT -
PHASE 4 MAIN HOSPITAL
BUILDING
900 CARLING AVE. OTTAWA ONTARIO

CLIENT
The Ottawa Hospital | L'Hôpital d'Ottawa

Infrastructure Ontario

PCL CONSTRUCTION | **EllisDon**

CLIENT PROJECT NO. 1070002

KEY PLAN
TRUE NORTH PROJECT NORTH

THIS DRAWING TO BE PRINTED IN COLOUR

NO.	DESCRIPTION	DATE
07	SITE PLAN CONTROL RESUBMISSION	2026-01-10
06	90% DD SUBMISSION	2025-06-19
05	SITE PLAN CONTROL RESUBMISSION	2025-04-05
04	65% DD SUBMISSION	2025-06-05
03	35% DD SUBMISSION	2025-01-28
02	ACFOR READINESS	2025-01-09
01	80% SD SUBMISSION	2024-08-15
00	ISSUED	DATE

REVISIONS

DRAWING STATUS
NOT FOR CONSTRUCTION

COORDINANCES MUST BE REPRINTED IMMEDIATELY TO THE ARCHITECT BEFORE PROCEEDING. ONLY FIGURED DIMENSIONS ARE TO BE USED. CONTRACTORS MUST CHECK ALL DIMENSIONS ON SITE. THIS DRAWING IS PROTECTED BY COPYRIGHT.

ALL DIMENSIONS ARE SHOWN IN METRIC.

AUTHOR
PWP

PROJECT TEAM
DESIGN/BUILDER: POLED, A JOINT VENTURE
ARCHITECTURAL: PARON ARCHITECTS LIMITED, ZOOH LAMARIE PRATTE ARCHITECTES, ADAMSON ASSOCIATE ARCHITECTS, BBS ARCHITECTS INC.
STRUCTURAL: STEPHENSON ENGINEERING LTD., SOUTHLETTET PARIZEAU INC.
MECHANICAL: HJ ANGLIS & ASSOCIATES LTD., CROSSEY ENGINEERING LTD.
ELECTRICAL: MELVEY & SWANN INTERNATIONAL INC.
CIVIL: WSP | PARSONS INC.
LANDSCAPE: VERDECO DESIGN INC., PWP LANDSCAPE ARCHITECTURE

BUILDING CODE UMG BUILDING CODE CONSULTANTS LTD.
AUTHOR PROJECT NO. PCL2301_C

STAMP
DRAWN: [] CHECKED: []
SCALE AT 40' x 60' DATE: 15-AUG-2024
GRAPHIC SCALE: []
DRAWING NO. L01-102 REV. NO. 07