


DATE PLOTTED: 15-AUG-2024 10:00:00 AM

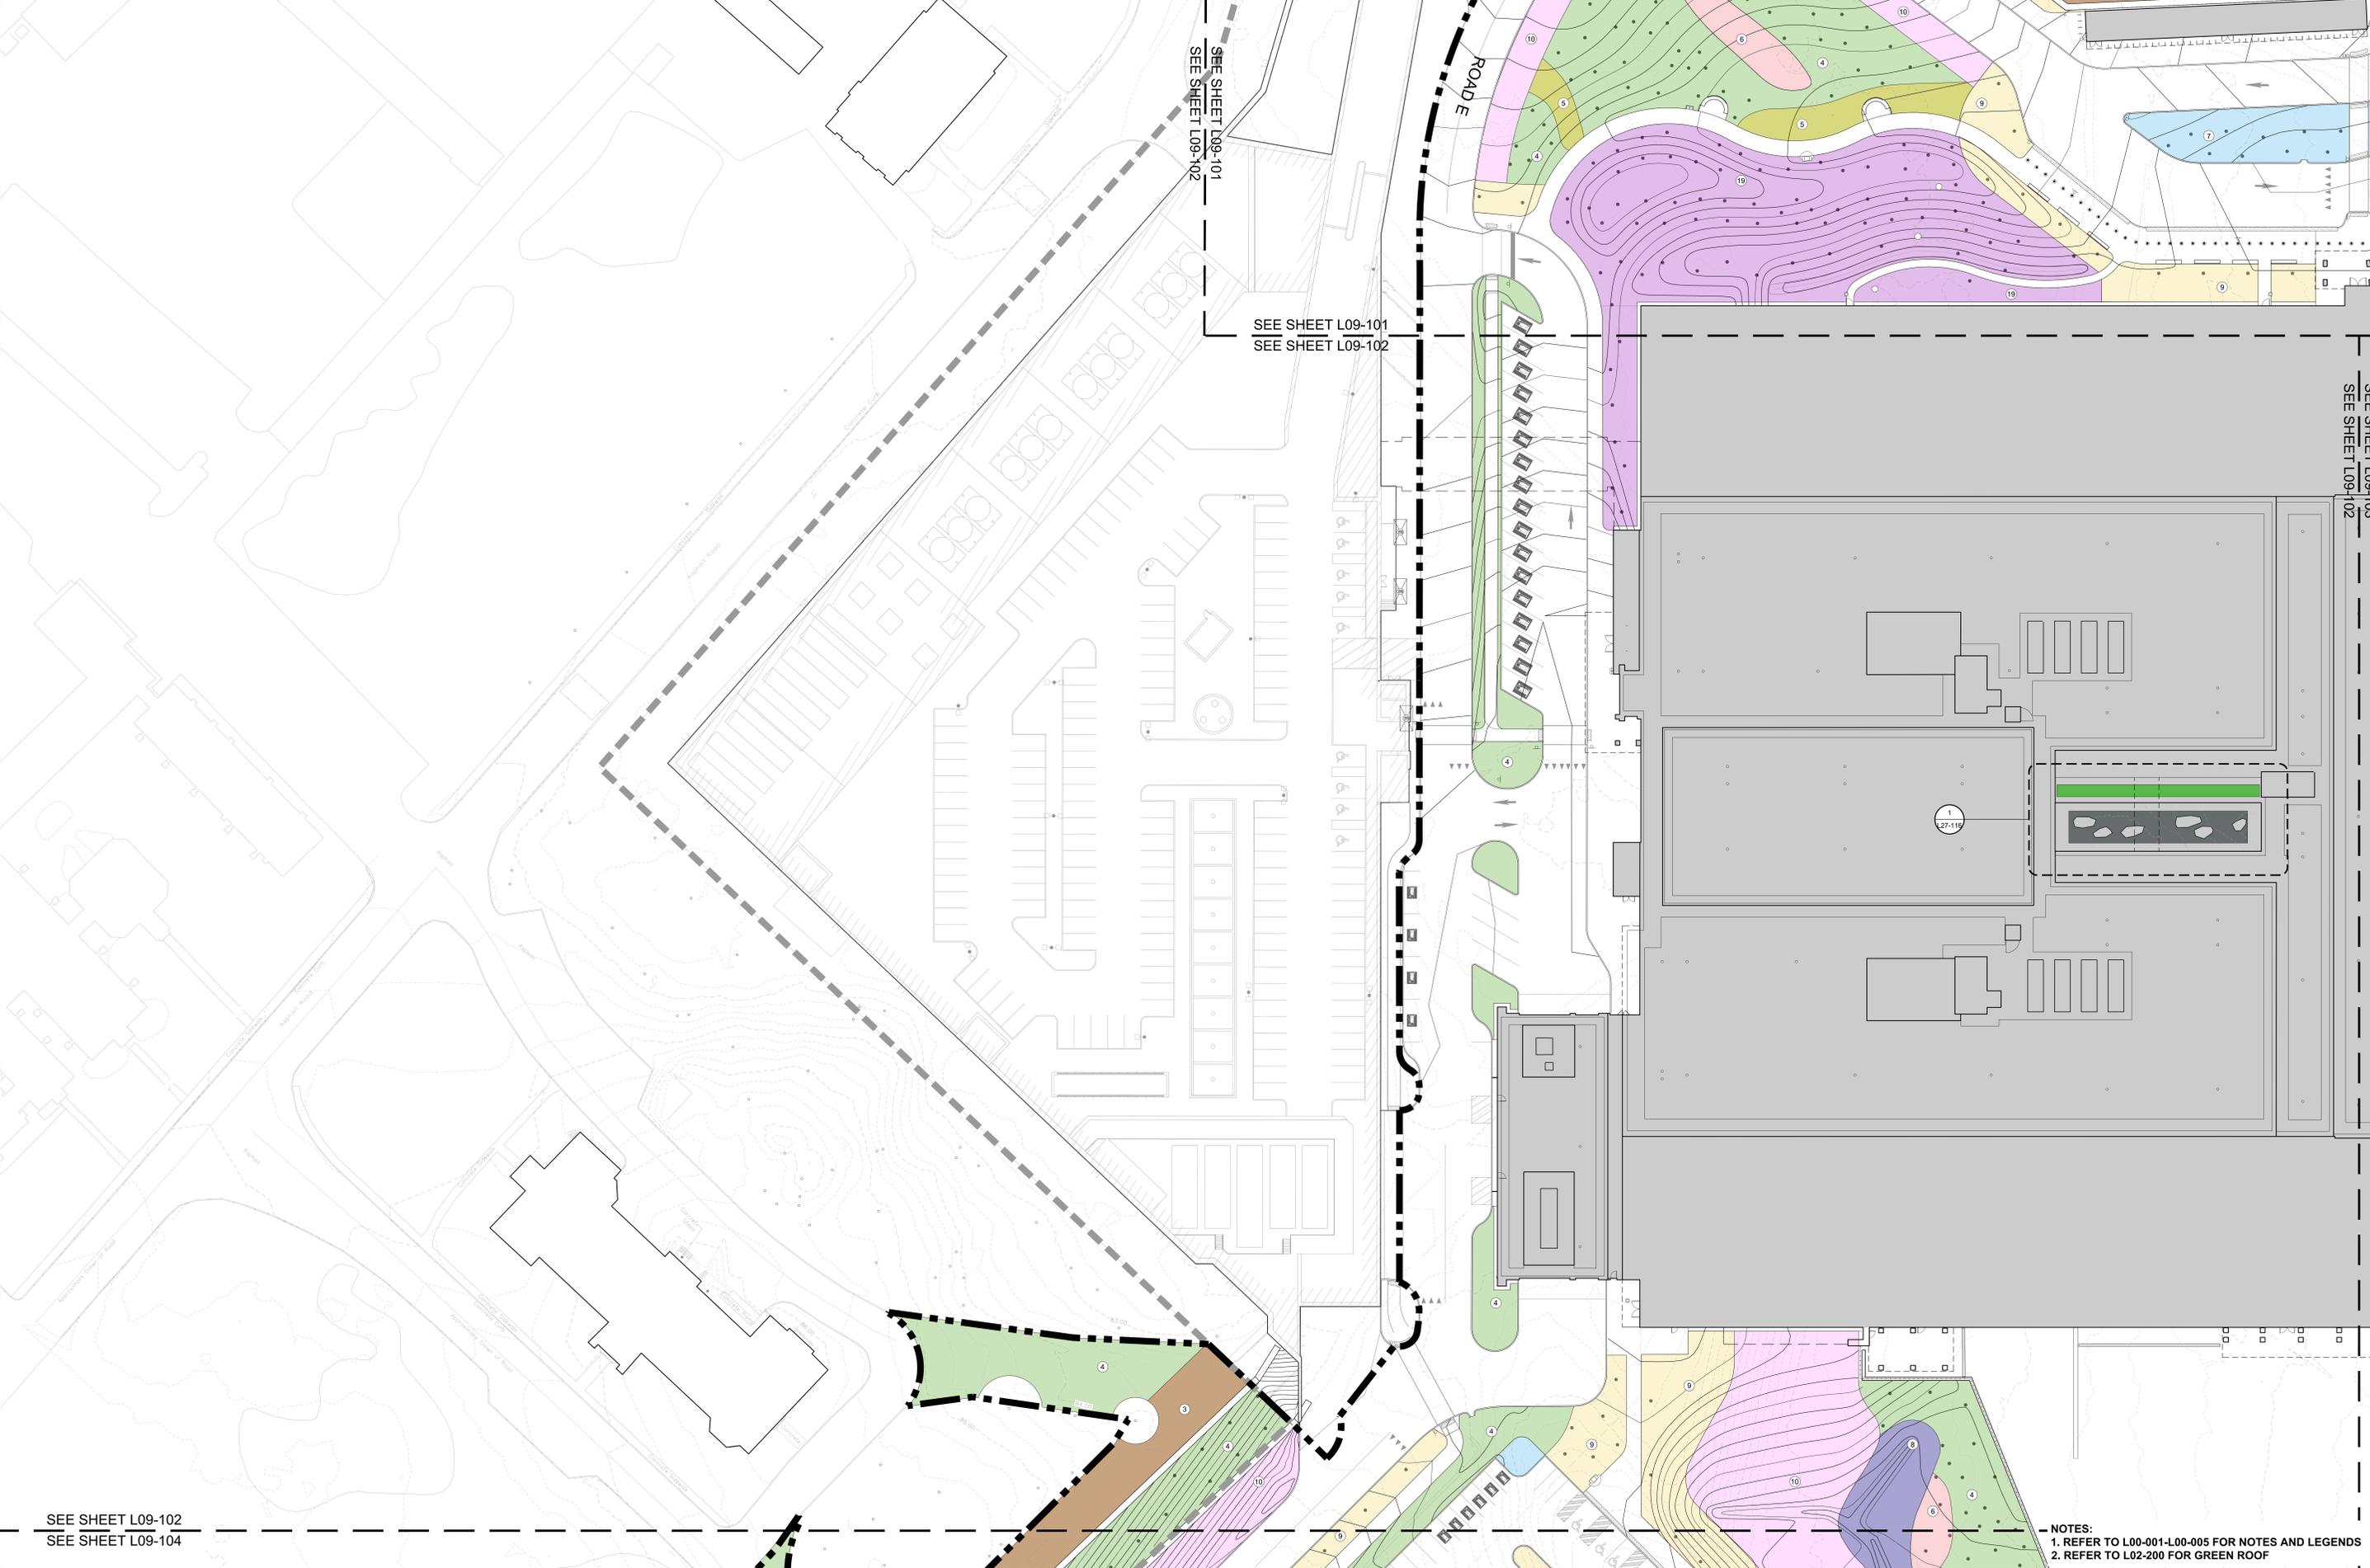

SEE SHEET L09-102
SEE SHEET L09-104

SEE SHEET L09-101
SEE SHEET L09-102

SEE SHEET L09-101
SEE SHEET L09-102

SEE SHEET L09-103
SEE SHEET L09-102

PROJECT
THE OTTAWA HOSPITAL
NEW CAMPUS
DEVELOPMENT -
PHASE 4 MAIN HOSPITAL
BUILDING
900 CARLING AVE. OTTAWA ONTARIO

CLIENT
The Ottawa Hospital | L'Hôpital d'Ottawa

INFRASTRUCTURE ONTARIO

PCL CONSTRUCTION | **EllisDon**

CLIENT PROJECT NO. 1070002

KEY PLAN
TRUE NORTH | PROJECT NORTH

THIS DRAWING TO BE PRINTED IN COLOUR.

07	SITE PLAN CONTROL RESUBMISSION	2026-01-10
06	90% DD SUBMISSION	2025-06-19
05	SITE PLAN CONTROL RESUBMISSION	2025-04-28
04	65% DD SUBMISSION	2025-06-26
03	35% DD SUBMISSION	2025-01-28
02	ACFOR READINESS	2025-01-09
01	80% SD SUBMISSION	2024-09-19
00	ISSUED	DATE

REVISIONS

DRAWING STATUS
NOT FOR CONSTRUCTION

DISCREPANCIES MUST BE REPORTED IMMEDIATELY TO THE ARCHITECT BEFORE PROCEEDING.
ONLY FIGURED DIMENSIONS ARE TO BE USED. CONTRACTORS MUST CHECK ALL DIMENSIONS ON SITE. THIS DRAWING IS PROTECTED BY COPYRIGHT.
ALL DIMENSIONS ARE SHOWN IN METRIC.

AUTHOR
PWP

PROJECT TEAM
DESIGN/BUILDER: PCL, A JOINT VENTURE
ARCHITECTURAL: PARON ARCHITECTS LIMITED, ZOOH LABARNE PRATTE ARCHITECTS, ADAMSON ASSOCIATE ARCHITECTS, 888 ARCHITECTS INC.
STRUCTURAL: STEPHENSON ENGINEERING LTD., BOUTHILLET PARIZEAU INC.
MECHANICAL: HJI ANGLIS & ASSOCIATES LTD., CROSSEY ENGINEERING LTD.
ELECTRICAL: MELVEY & BIRN INTERNATIONAL INC., HEP SWANBY INC.
CIVIL: HEP SWANBY INC.
LANDSCAPE: VERTECOBS DESIGN INC., PWP LANDSCAPE ARCHITECTURE
BUILDING CODE: UMOG BUILDING CODE CONSULTANTS LTD.
AUTHOR PROJECT NO.: **PCL2301_C**

STAMP

DRAWING TITLE
UNDERSTORY PLANTING PLAN

DRAWN	CHECKED
SCALE AT 40' x 60'	DATE
1:250	15-AUG-2024
GRAPHIC SCALE	SCALE IN METERS

NOTES:
1. REFER TO L00-001-L00-005 FOR REVES AND LEGENDS
2. REFER TO L02-200 FOR GREEN ROOF

DRAWING NO. L09-102 | **REV NO.** 07