

THIS DRAWING, OR PARTS THEREOF, MAY NOT BE REPRODUCED OR USED IN ANY FORM, BY ANY METHOD, FOR ANY PURPOSE, WITHOUT THE WRITTEN PERMISSION OF QUADRANT ENGINEERING.

THIS DRAWING IS TO BE READ IN CONJUNCTION WITH THE SPECIFICATION, WHERE CONFLICT ARISES THE MORE STRINGENT OF THE TWO SHALL APPLY.

COPYRIGHT © 2020 QUADRANT ENGINEERING.

THE ELECTRICAL CONTRACT DOCUMENTS ARE THE PROPERTY OF QUADRANT ENGINEERING LIMITED (QE)


THE CONTRACTOR SHALL OBTAIN A FULL SET OF ALL CONSULTANTS' DESIGN DOCUMENTS PRIOR TO STARTING WORK.

QE BEARS NO RESPONSIBILITY FOR INTERPRETATIONS OF THESE DOCUMENTS BY OTHERS.

UPON WRITTEN APPLICATION QEL WILL PROVIDE WRITTEN CLARIFICATION REGARDING THE INTENT OF THE CONTRACT DOCUMENTS.

QE REVIEW OF SHOP DRAWINGS SUBMITTED BY THE CONTRACTOR IS FOR DESIGN CONFORMANCE ONLY.

DRAWINGS ARE NOT TO BE SCALED FOR CONSTRUCTION. CONTRACTOR TO VERIFY ALL CONDITIONS AND DIMENSIONS, ON SITE, REQUIRED TO PERFORM THE WORK AND REPORT ANY DISCREPANCIES WITH THE CONTRACT DOCUMENTS TO THE DESIGN TEAM BEFORE COMMENCING WORK.

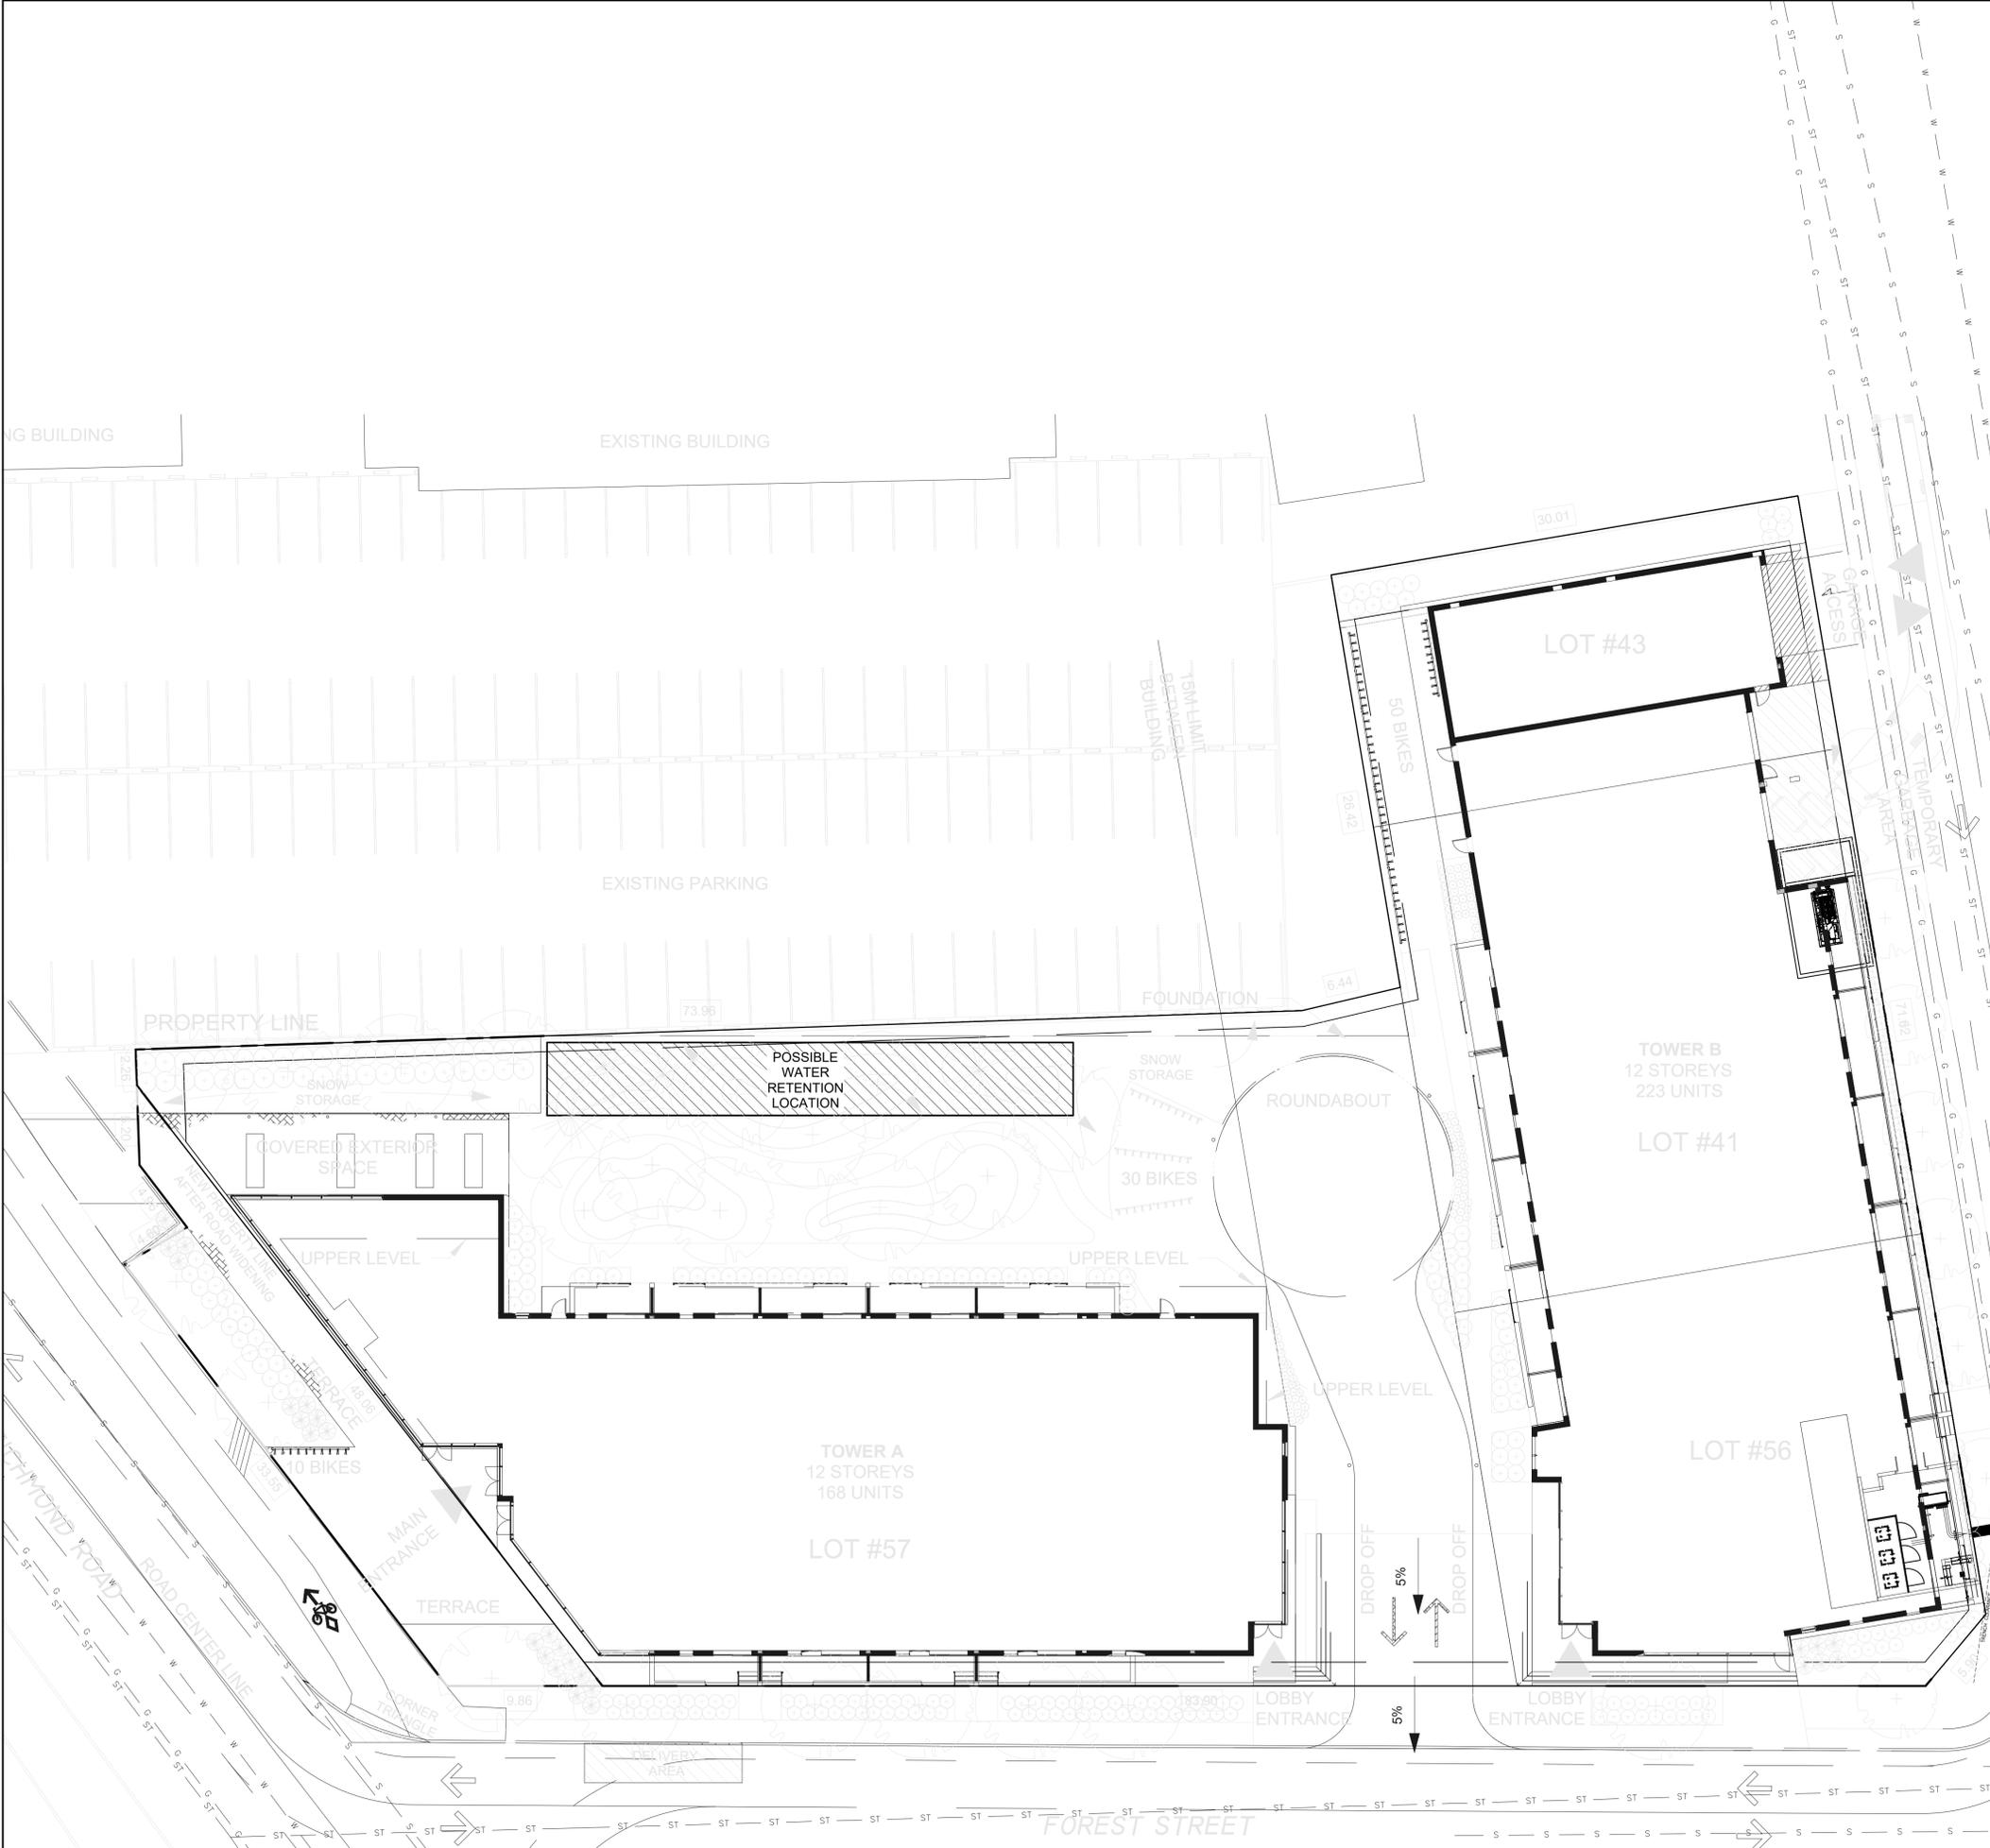

5	ISSUED FOR SITE PLAN COORDINATION	22 OCT 2021
3,4	NOT USED	-
2	ISSUED FOR COORDINATION	29 JAN 2021
1	ISSUED FOR DESIGN BRIEF	21 DEC 2020
NO.	REVISION	DATE

5	ISSUED FOR SITE PLAN COORDINATION	22 OCT 2021
3,4	NOT USED	-
2	ISSUED FOR COORDINATION	29 JAN 2021
1	ISSUED FOR DESIGN BRIEF	21 DEC 2020
NO.	REVISION	DATE

365 FOREST ST
TOWER A AND B

QUADRANT
an Inteletric Company

2283 ST LAURENT BLVD. UNIT 203, OTTAWA, ONTARIO, K1G 5A2
TEL. (613) 567-1487 FAX. (613) 567-1493
E-Mail: mail@quadrantengineering.ca

CURRENT DATE	Fri, 22 Oct 2021, 08:26
SCALE	1:200
DRAWN	BML
DESIGNED	BML
CHECKED	MC
PROJECT	QE 20-0086
DRAWING NUMBER	E-001

ELECTRICAL SITE PLAN